

Single Wood Door 70.0 EA
Twin Wood Door 2.0 EA
Wall Paint (12'-0" H) 1503.6 FT
Wall Paint (8'-0" H) 1092.5 FT

GENERAL NOTES:

- REFER TO HOMEWOOD STANDARDS FOR FLOORING REQUIREMENTS IN EACH AREA.
- ALL WALLS IN BATH SHALL BE MOISTURE RESISTANT GYPSUM BOARD. BATH CEILING SHALL BE EXTERIOR GYPSUM BOARD.
- WALL CONSTRUCTION SHOWN FOR REFERENCE ONLY. DESIGNER OF RECORD SHALL DETERMINE WALL CONSTRUCTION, STRUCTURES, METHOD OF STC COMPLIANCE, ETC.
- ACCESSIBLE CLEARANCES INDICATED IN THESE DRAWINGS ARE FOR DESIGN INTENT ONLY. DESIGNER OF RECORD SHALL BE RESPONSIBLE FOR COMPLIANCE WITH ACCESSIBILITY REQUIREMENTS PER LOCAL AND NATIONAL CODES.
- ACCESSIBLE GUEST ROOMS WITH MOBILITY FEATURES MUST INCLUDE A MINIMUM NUMBER OF ROOMS AND SUITES WITH ROLL-IN TYPE SHOWER STALLS. THE NUMBER IS BASED ON THE 2010 ADA STANDARDS AND LOCAL CODE.
- BOTH VISUAL AND NOTIFICATION DEVICES SHALL BE PROVIDED IN PUBLIC AND COMMON AREAS. THE SYSTEM MUST BE DESIGNED TO BE ABLE TO BE INTEGRATED INTO EMPLOYEE WORK SPACES AND MUST COMPLY WITH NFPA 72 AND STATE, LOCAL AND FEDERAL REGULATIONS. DEVICES MUST BE LOCATED SO THE LIGHT IS VISIBLE IN EACH REQUIRED SPACE.
- PROVIDE AN ACCESSIBLE ROUTE AND COMPLIANT WHEELCHAIR LOCATIONS IN EACH OF THE PUBLIC SPACES PROVIDED FOR GUEST USE.

CEILING LEGEND:

8'-6" Q
CEILING FINISH

A.	PRIMED & PAINTED GYPSUM BOARD
B.	PRIMED & PAINTED GYPSUM BOARD - MOISTURE RESISTANT
C.	OPEN TO UNDERSIDE OF FLOOR / ROOF SYSTEM ABOVE - PAINT ALL ELEMENTS - ELEVATION INDICATED MAY BE "APPROXIMATE" & FOR GENERAL REFERENCE ONLY - REFER TO SECTIONS
D.	<NOT USED>
E.	2X2 LAY-IN CLG. GRID SYSTEM SUSPENDED FROM STRUCT. - BASIS OF DESIGN ARMSTRONG DUNE TEGULAR CLG. TILE W/ 9/16" GRID
F.	<NOT USED>
G.	FIBER CEMENT PANEL SOFFIT
H.	WOOD-LOOK FIBER CEMENT PANELS
J.	PRE-FINISHED WOOD VENEER WALL COVERING
K.	ENGINEERED WOOD STRUCTURAL SYSTEM

LIGHT FIXTURE LEGEND

GR-A (6" RECESSED SQUARE FLANGED DOWNLIGHT WITH NEW CONSTRUCTION HOUSING)

ID - SURFACE MOUNTED ARCHITECTURAL UP/DOWN WALL SCONCE (REFERENCE FF&E SPEC)

XS-C (SURFACE MOUNTED STATIC COLOR LED ARCHITECTURAL UPLIGHT (WET LOCATION) | 15.5 WATTS, 0-10V)

XS-D (EXTERIOR DECORATIVE WALL SCONCE)

SYMBOL / FIXTURES KEY

ACCESSIBLE ROOM

COMMUNICATION FEATURES ROOM - REFER TO ENLARGED GUESTROOM PLANS FOR POWER AND SIGNAL

MAGNETIC DOOR HOLD OPENER TIED TO BUILDING ALARM SYSTEM - REFER TO DOOR SCHEDULE, ELEC. & ALARM DRAWINGS

FURNISHINGS LEGEND:

PA-100	BANQUETTE
PA-101	DINING CHAIR AT BANQUETTE
PA-103	BARREL BACK LOUNGE CHAIR
PA-104	LOUNGE CHAIR AT MAIN DINING
PA-105	COUNTER HEIGHT STOOL AT WINDOW SEATING
PA-106	DINING CHAIR
PA-107	COUNTER STOOL AT PANTRY
PA-108	COUNTER STOOL AT COMMUNAL TABLE
PA-109	SECTIONAL
PA-110	LOUNGE CHAIR AT LIVING ROOM
PA-111	BENCH AT ENTRY
PA-112	BANQUETTE AT GUEST LAUNDRY
PA-113	DINING CHAIR AT BOH BREAKROOM
PA-114	BENCH AT FITNESS
PA-200	PENDANT AT RECEPTION
PA-201	FLOOR LAMP AT CENTRAL HUB
PA-202	PENDANT AT PANTRY
PA-203	PENDANT AT PUBLIC RESTROOM
PA-204	SCONCE AT CORRIDOR
PA-300	RECTANGULAR DINING TABLE
PA-301	HIGH 4-TOP DINING TABLE
PA-302	TEA HEIGHT DINING TABLE
PA-303	DINING TABLE
PA-304	COMMUNAL TABLE AT WINDOWS
PA-305	PANTRY INDUCTION TABLE
PA-306	COMMUNAL TABLE AT LIVING ROOM
PA-307	COCKTAIL TABLE AT LIVING ROOM
PA-308	TABLE AT LAUNDRY LOUNGE
PA-309	SIDE TABLE AT SECTIONAL AT LIVINGROOM
PA-310	COFFEE STATION AT LIVING ROOM
PA-311	ENTERTAINMENT CONSOLE AT LIVINGROOM
PA-312	DINING TABLE AT BREAK ROOM - ADA

SCREEN AT ENTRY
SCREEN AT PANTRY
PRINTER CABINET AT LIVING ROOM
ROLLER SHADE FABRICATION AT CENTRAL HUB
ROLLER SHADE FABRICATION AT GUEST LAUNDRY
ROLLER SHADE FABRICATION AT FITNESS
ROLLER SHADE FABRICATION AT BREAK ROOM
ROLLER SHADE FABRICATION AT CORRIDOR
ART GROUPING AT CENTRAL HUB
ART AT PUBLIC RESTROOM (MEN'S)
ART AT PUBLIC RESTROOM (WOMEN'S)
ART AT GUEST LAUNDRY LOUNGE
ART AT GUEST FLOOR ELEVATOR LOBBIES
MIRROR AT PUBLIC RESTROOM VANITY
FULL LENGTH MIRROR AT MAIN PUBLIC RESTROOM
DECORATIVE HOOKS - FITNESS
ACCESSORIES AT ENTERTAINMENT WALL
OUTDOOR LOUNGE CHAIR
OUTDOOR LOUNGE CHAIR AT FIRE FEATURE
OUTDOOR DINING CHAIR
OUTDOOR COUNTER STOOL
PENDANT AT BACKYARD KITCHEN
OUTDOOR SIDE TABLE
OUTDOOR SIDE TABLE AT FIRE FEATURE
OUTDOOR PICNIC TABLE
OUTDOOR DINING TABLE


FINISH LEGEND

ACT ACoustic CEILING TILE
CP CARPET
CPP CARPET PAD
CT TILE (PORCELAIN)
PL PLASTIC LAMINATE
PT PAINT
QT QUARRY TILE
RB RUBBER BASE
RES RESILIENT TILE FLOOR
SS ENGINEERED STONE
ST STONE
WC WALLCOVERING
WD STAIN GRADE WOOD VENEER
WP CORNER GUARD

NOTE:
REFER TO FF&E PACKAGE FOR FURNITURE AND FINISH SPECIFICATIONS

KEY NOTES

- ELEVATOR CAB SHALL PROVIDE EMERGENCY ACCESS TO ALL FLOORS AND ACCOMMODATE AMBULANCE STRETCHER WHEN REQUIRED BY CODE. SHAFT STRUCTURE TO BE CMU.
- PROVIDE ENCLOSED ROOM FOR LINEN CHUTE WHEN REQUIRED BY CODE.
- SAFE
- MAKE UP AIR
- PROVIDE ENCLOSED ROOM FOR LINEN CHUTE WHEN REQUIRED BY CODE. LINEN CHUTE MUST BE INSULATED.
- HOLD-OPEN FIRE DOORS - AS REQUIRED BY CODE
- HOSE BIB
- GUEST STORAGE LOCKERS
- LINEN CHUTE
- FIRE EXTINGUISHER (CABINET IN PUBLIC AREAS), INSTALLED SO THAT NO OPERABLE PART IS HIGHER THAN 48" A.F.F.
- NOT USED
- ALTERNATING TREAD STAIR AND ROOF HATCH AT TOP FLOOR ONLY - REFER ALSO TO ROOF PLAN.
- ACCESSIBLE ICE & WATER MACHINE WITH REQUIRED ACCESSIBLE APPROACH AREA - PROVIDE FLOOR DRAIN CENTERED UNDER ICE MACHINE AND PROVIDE POSITIVE SLOPE TOWARDS DRAIN WITHOUT AFFECTING ACCESSIBLE REQUIREMENTS. INSULATE DRAIN PIPES.
- GUEST LAUNDRY DRYER (DIRECT VENT TO EXTERIOR)
- GUEST LAUNDRY WASHER
- SLAB DEPRESSION REQUIRED AT COOLER
- INDICATES DIRECTION OF CARPET PATTERN. REFER TO MFR FOR DIRECTION
- ROOM SIGNAGE AND SCONCE NOT TO PROJECT MORE THAN 4" MAX FROM FINISHED FACE OF WALL

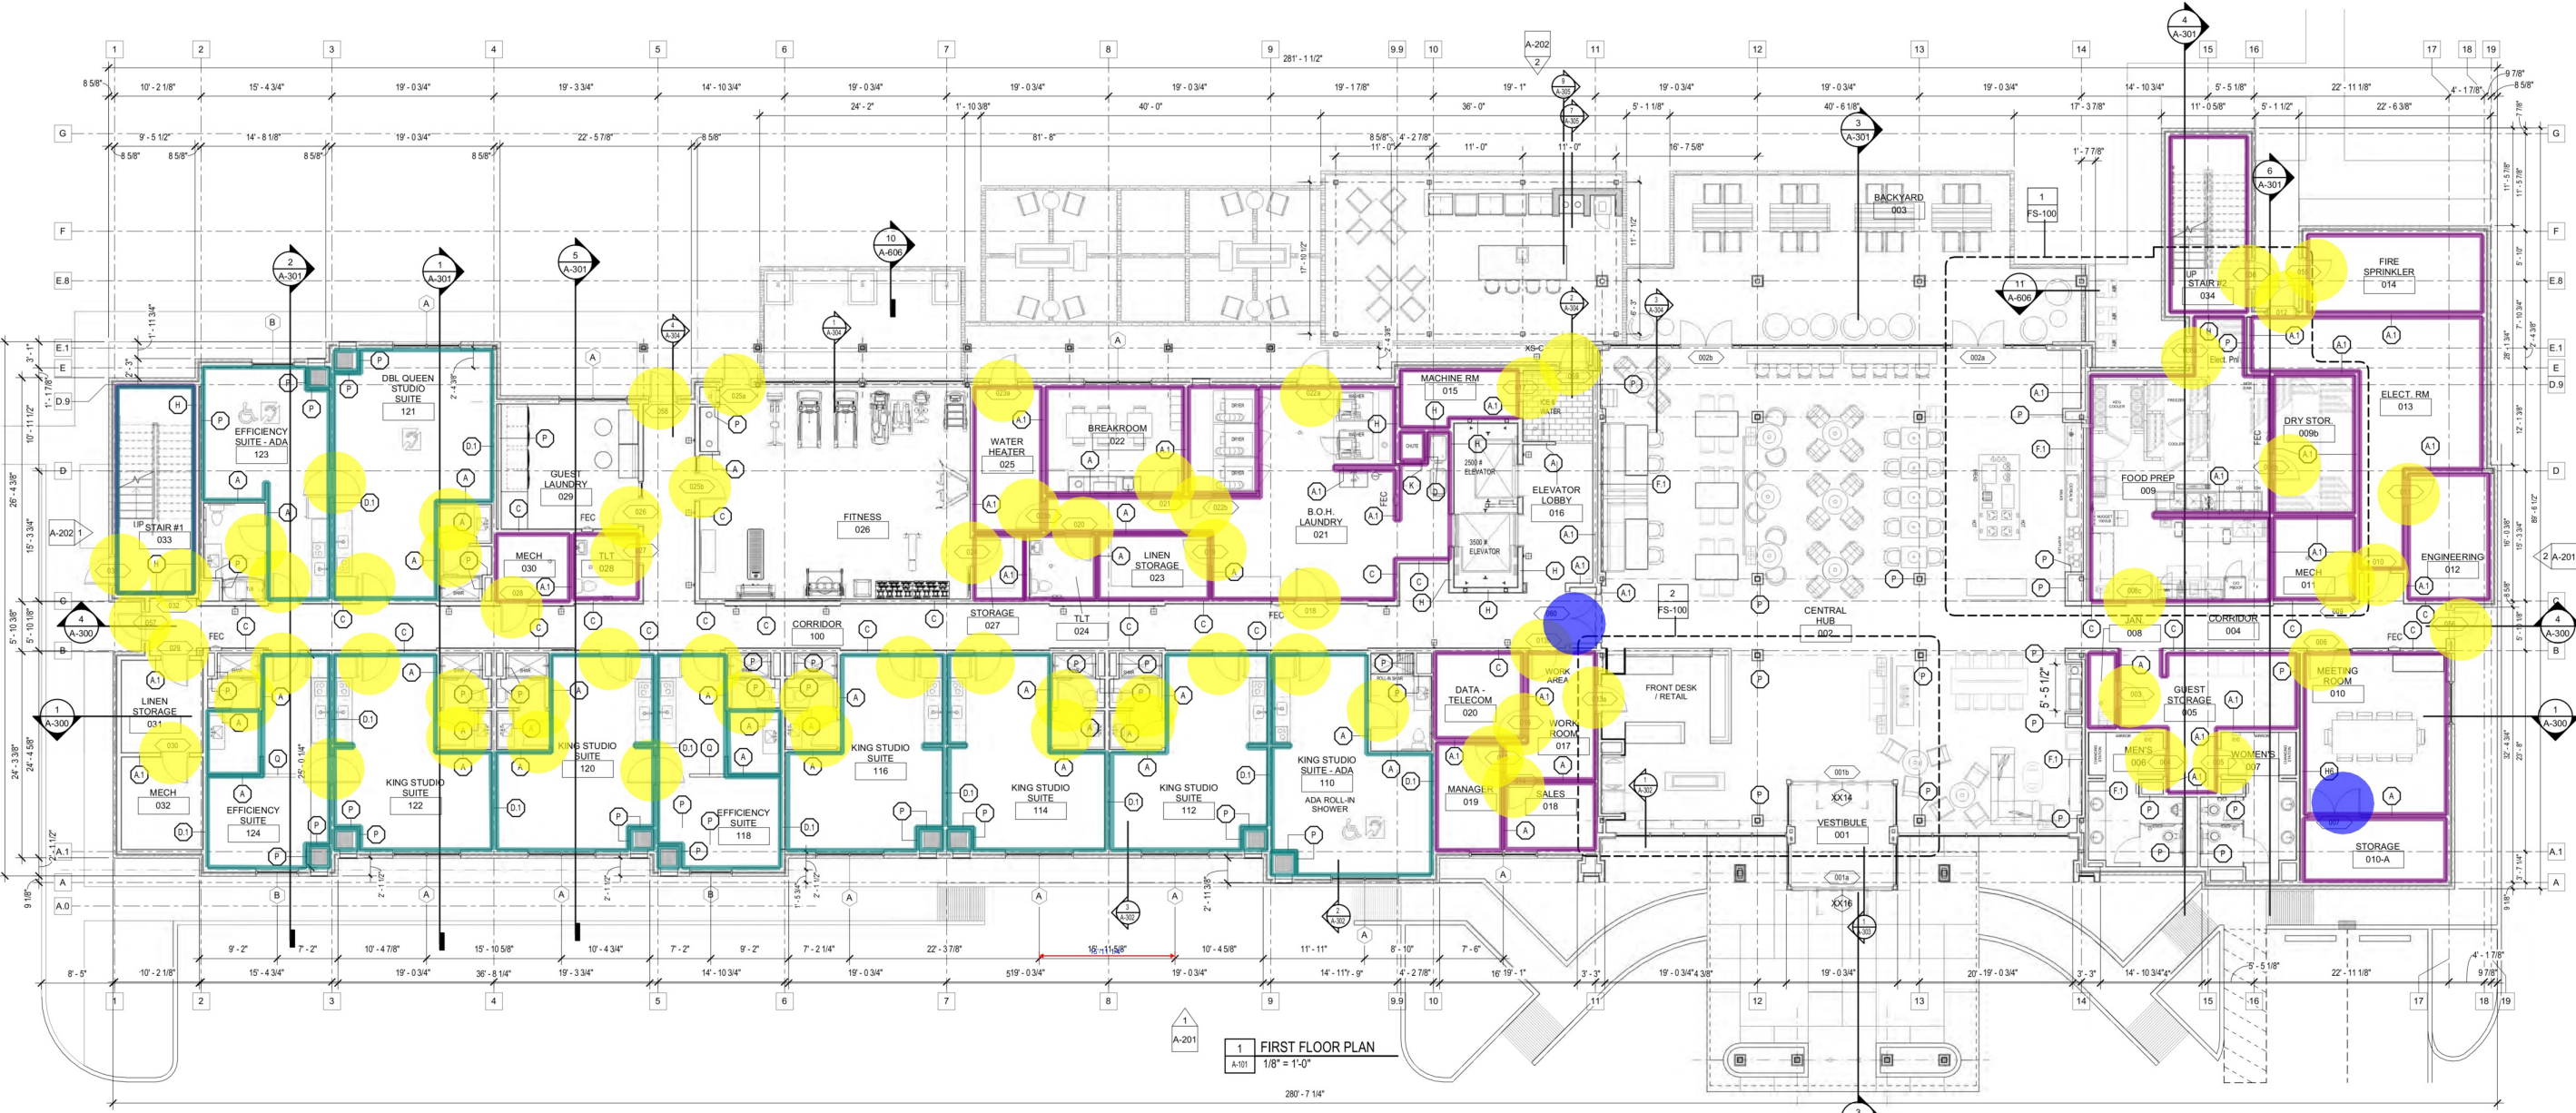

Holyfield Construction, Inc.
2371 Tower Drive, Monroe, LA 71201

Lonnie E. Patrick
ARCHITECT
1000 PRENTICE PARQUE ROAD
DOWNSVILLE, LOUISIANA 71234
Ph: 225-374-9001
Lonnie@holyfield.com

Expires: 12-1-2026

HOMEWOOD Suites by Hilton
310 THOMAS ROAD
WEST MONROE, LOUISIANA 71291
PROJECT NO. 23-670ND / 60816
REVISIONS


02-20-26

1st FLOOR PLAN

SHEET NO. A-101
CONSTRUCTION DOCUMENTS

Single Wood Door
Wall Paint (8'-0" H)


89.0 EA
3448.8 FT

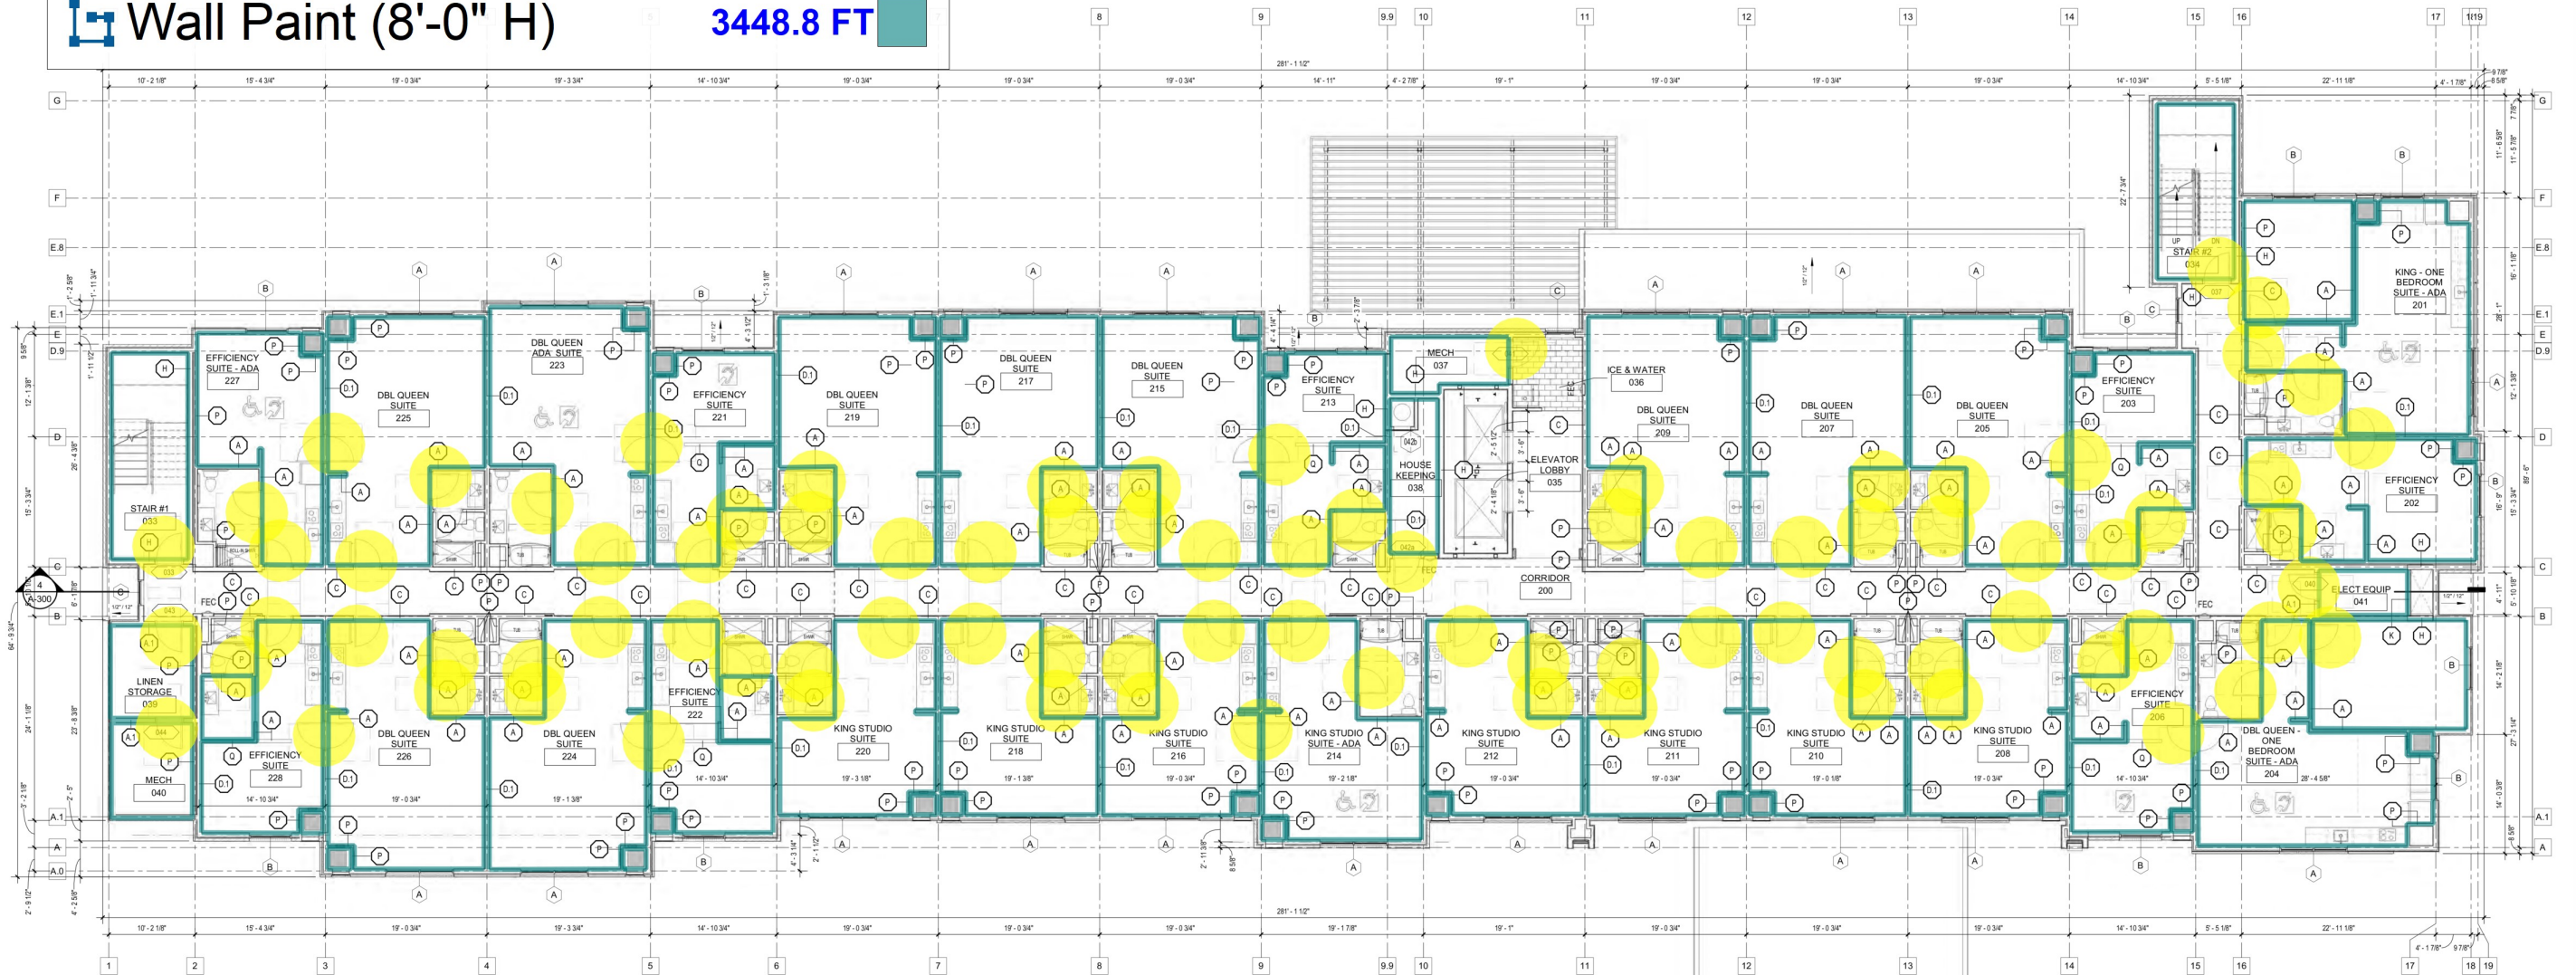

1 SECOND FLOOR PLAN
1/8" = 1'-0"

\\hollyfield\local\Shared\Users\Patrick\Documents\Patric prop. Thomas Road-Monroe - ARCH - V2 - HWS - BldgRev - LEP\ArchA1.rvt

 Hollyfield Construction, Inc.
2271 Tower Drive, Monroe, LA 71201



Lonnie E. Patrick
ARCHITECT
1000 PRENTICE PARQUE ROAD
DOWNSVILLE, LOUISIANA 71234
Ph: 225-374-4001
www.hollyfieldinc.com



HOMEWOOD
SUITES by Hilton
755 CROSSOVER LN. MEMPHIS TN 38117
P: 901.374.5800

New Construction for
HOMEWOOD Suites by Hilton
310 THOMAS ROAD
WEST MONROE, LOUISIANA 71291


PROJECT NO.
23-670ND / 60816
REVISIONS

02-20-26

2nd FLOOR PLAN

SHEET NO.
A-102
CONSTRUCTION
DOCUMENTS

92.0 EA 
3445.9 FT 

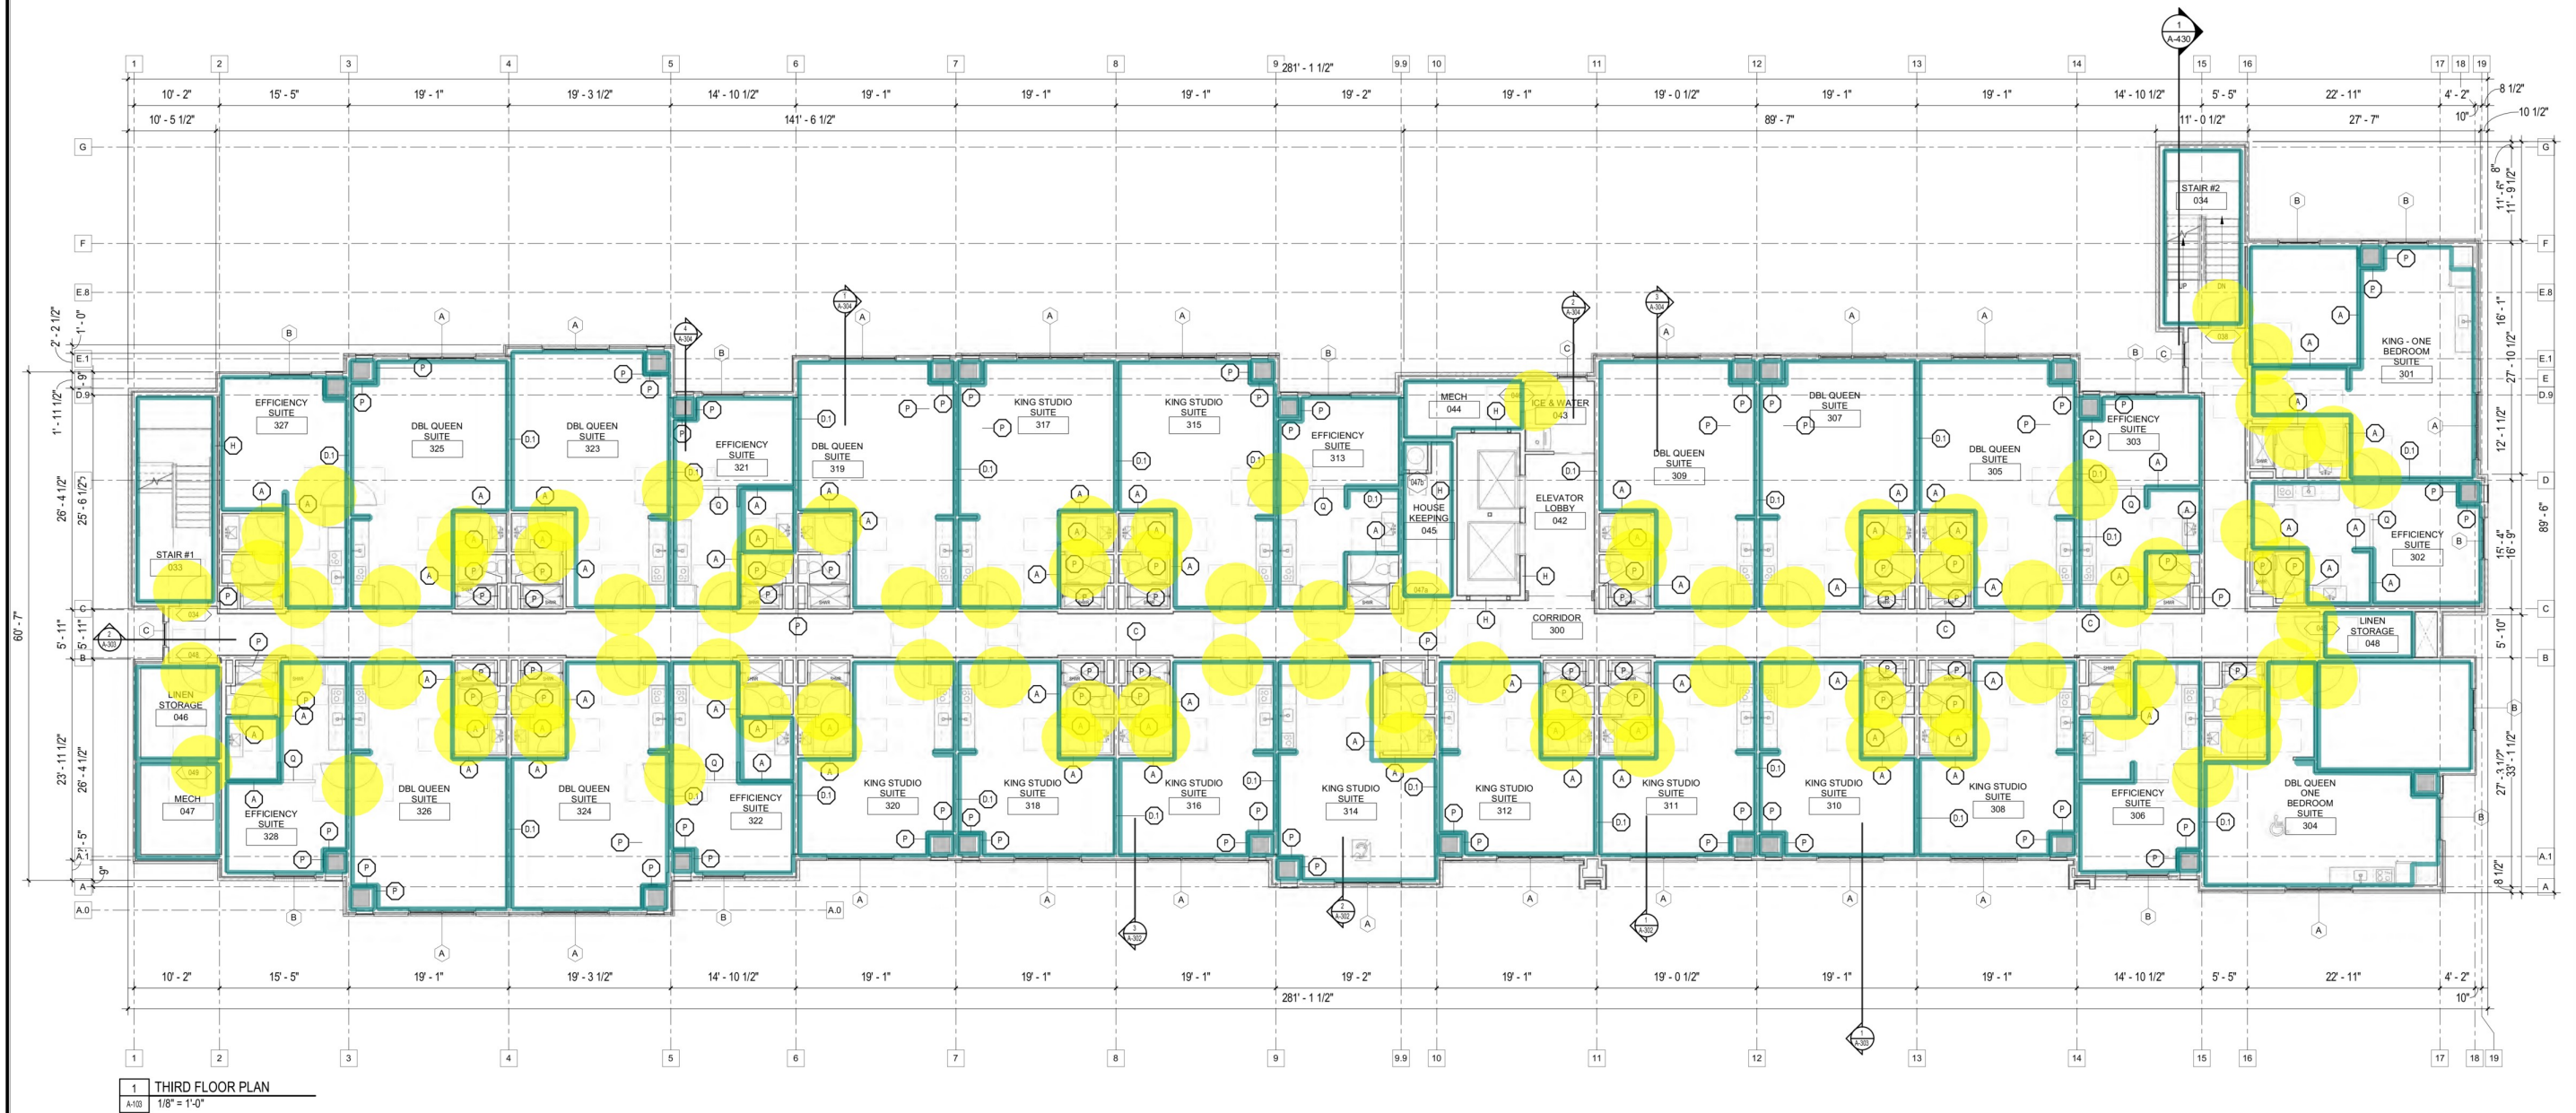




Single Wood Door



Wall Paint (8'-0" H)


93.0 EA

3445.9 FT

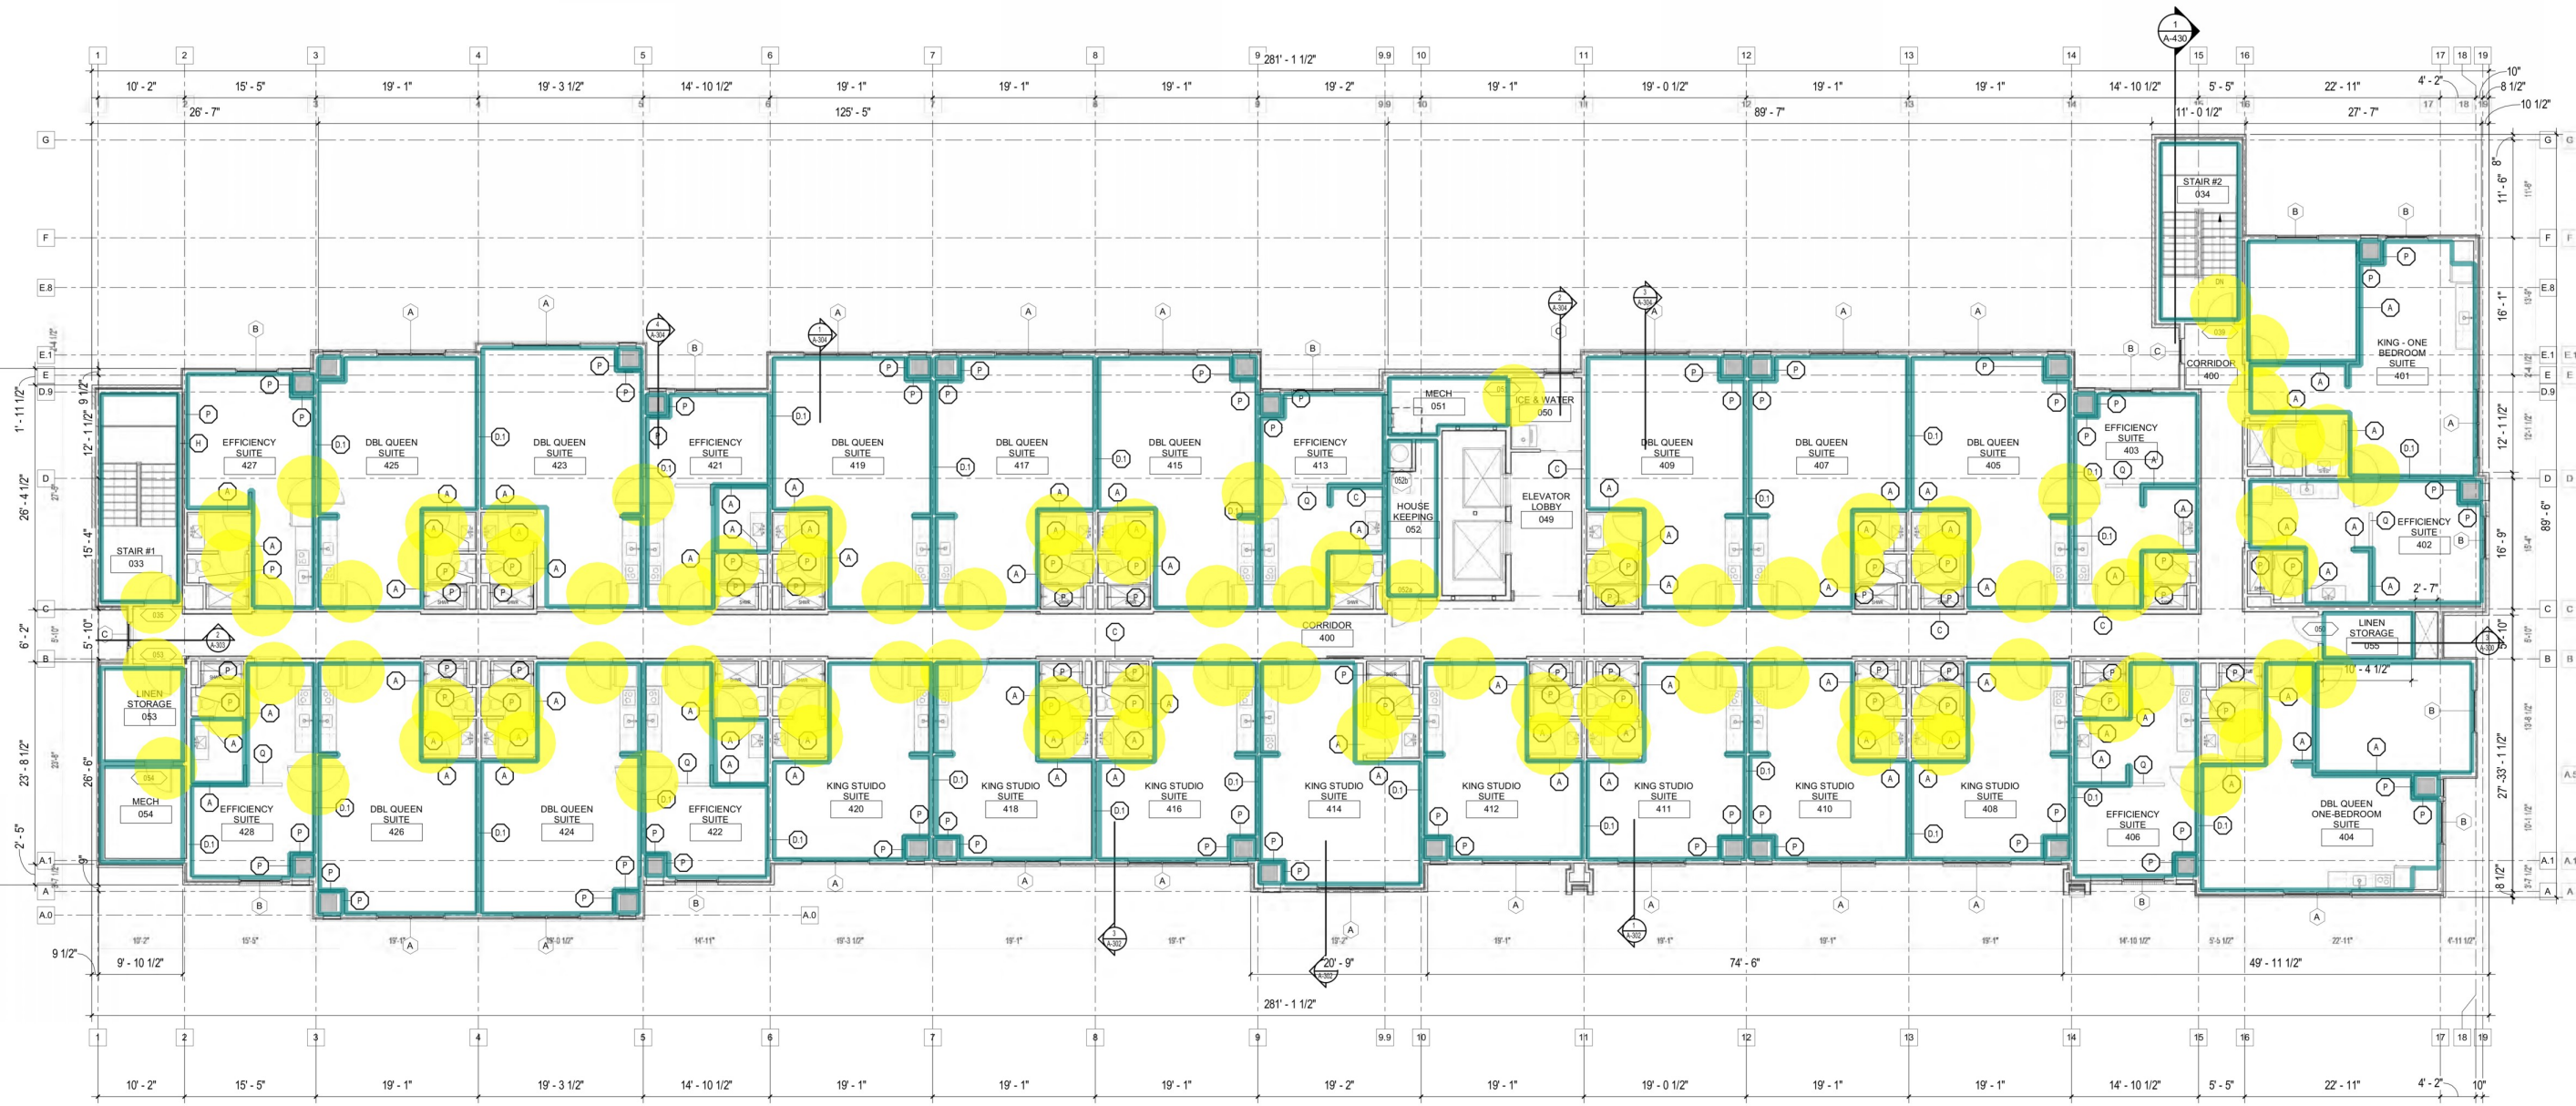

1 FOURTH FLOOR PLAN
A-104
1/8" = 1'-0"

 Holyfield Construction, Inc.
2371 Tower Drive, Monroe, LA 71201



Lonnie E. Patrick
ARCHITECT
1000 PRENTICE PARQUE ROAD
DOWNSVILLE, LOUISIANA 71234
Ph: 337.374.5001
www.holyfieldinc.com



Expires: 12-31-2026

NEW CONSTRUCTION FOR
HOMEWOOD Suites by Hilton
310 THOMAS ROAD
WEST MONROE, LOUISIANA 71291

PROJECT NO.
23-670ND / 60816


REVISIONS

02-10-2026

4th FLOOR PLAN

SHEET NO.
A-104
CONSTRUCTION DOCUMENTS

\\holyfield\local\Shared\Users\Patrick\Documents\Hill Prop. Thomas Road-M Monroe - ARCH - V2 - HWS_BldgRev_LEP\Rev_A\A120

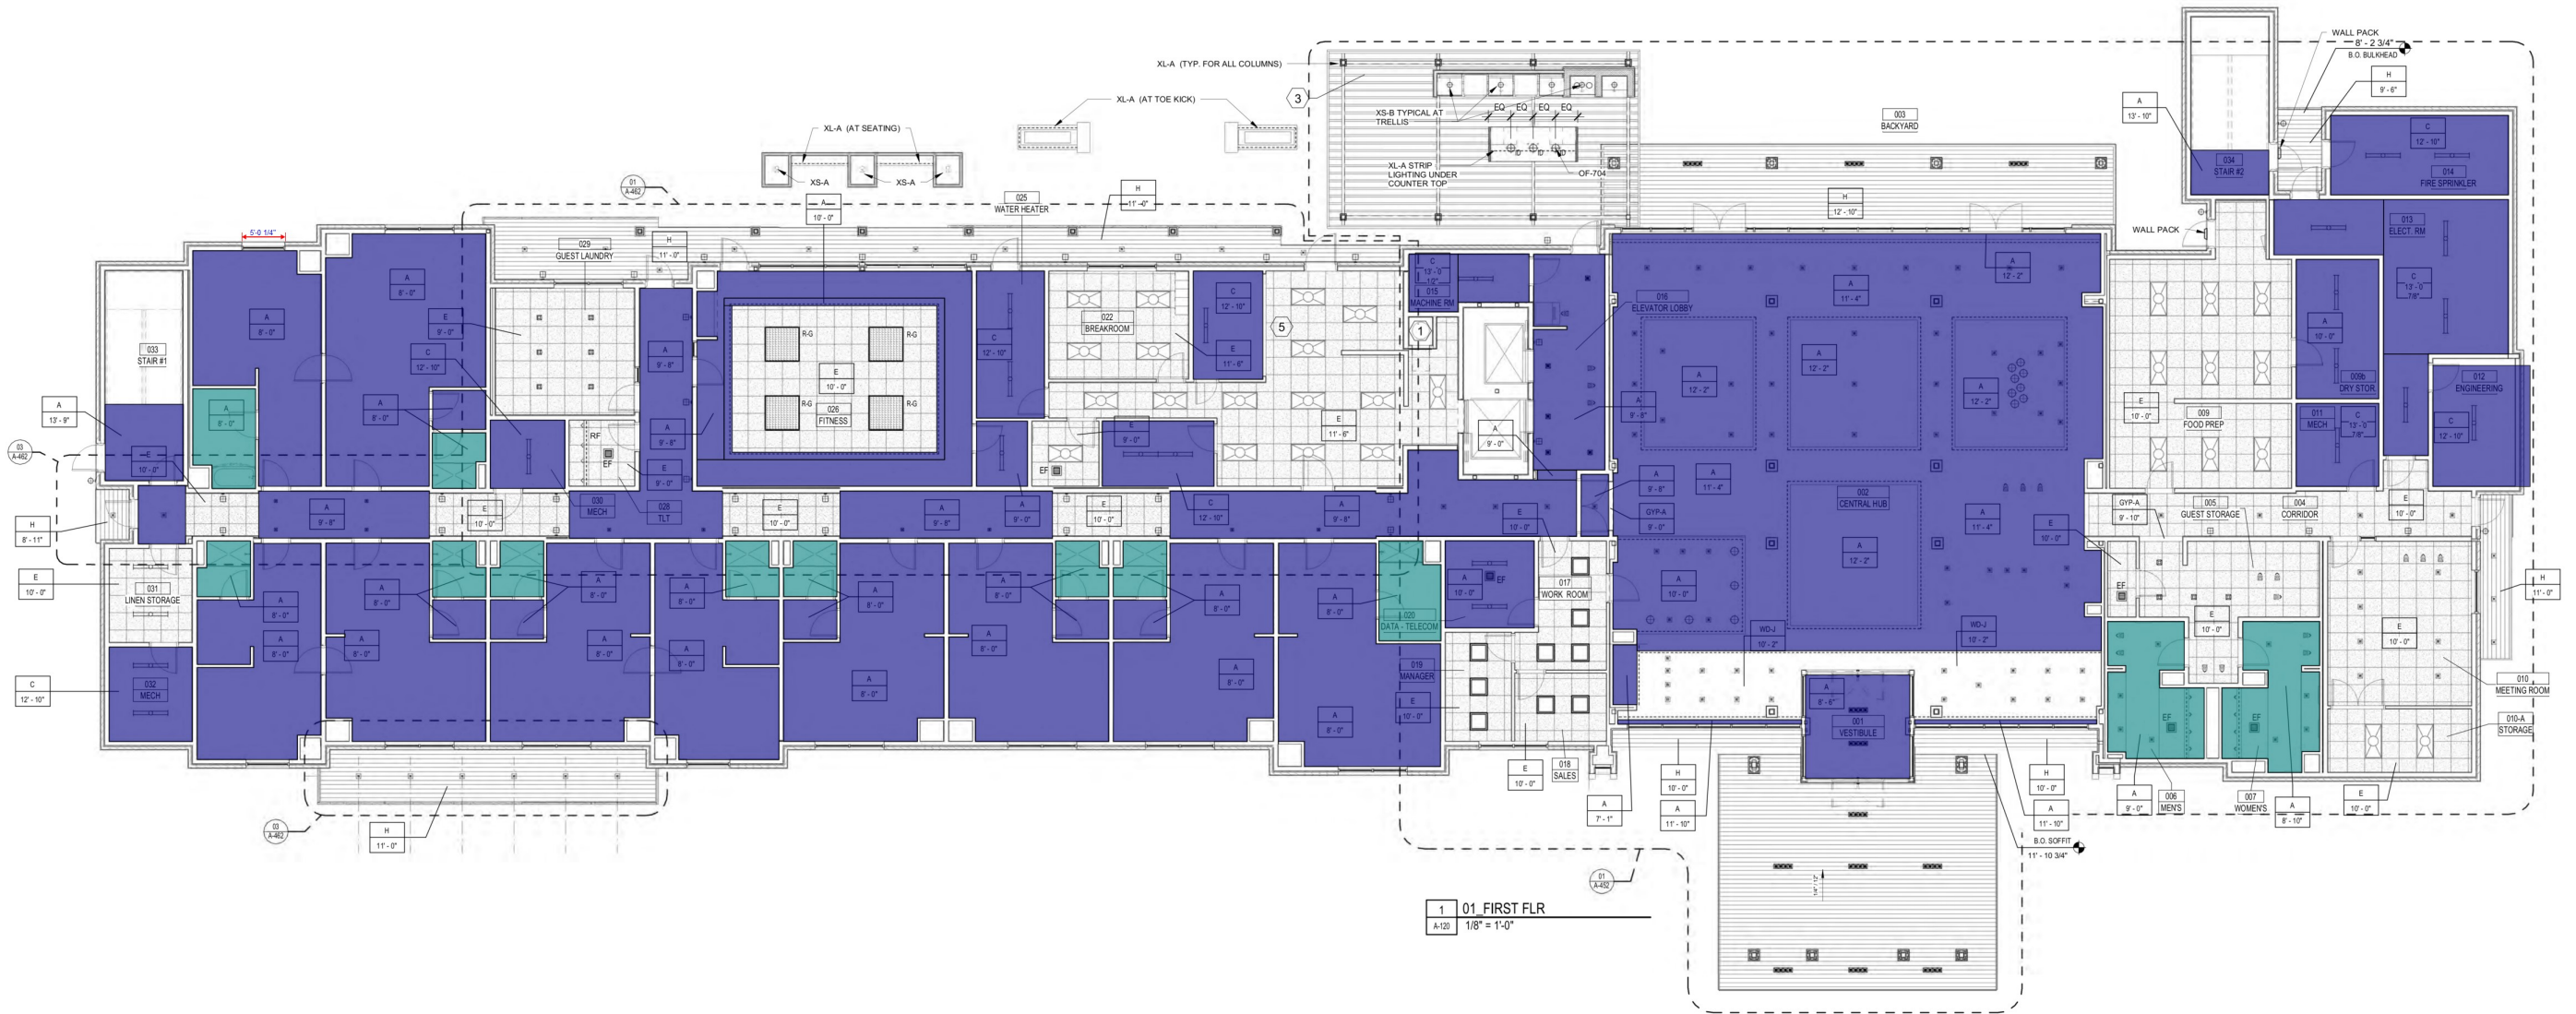

 Paint Gypsum Board Ceiling
 Paint on MR Gypsum Board Ceiling

9819.3 SQ FT
757.1 SQ FT


LIGHT FIXTURE LEGEND:	
	2X2 LIGHT FIXTURE
	2X4 LIGHT FIXTURE
	SURFACE MOUNTED LIGHT FIXTURE
	WALL MOUNTED LIGHT FIXTURE
	R-A RECESSED FLANGED SQUARE WARM-DIM LED ADJUSTABLE 15 WATTS, MLV/FWD
	R-B RECESSED FLANGED SQUARE WARM-DIM LED ADJUSTABLE 15 WATTS, MLV/FWD
	R-C RECESSED FLANGED SQUARE WARM-DIM LED WASH 15 WATTS, MLV/FWD
	R-D RECESSED RECTILINEAR WARM-DIM FLANGED DOWNLIGHT 15 WATTS, MLV/FWD
	R-E RECESSED FLANGED SQUARE WARM-DIM LED DOWNLIGHT WITH LUMINOUS LENS 12 WATTS, MLV/FWD
	R-F RECESSED LINEAR LED WARM-DIM LED WASH SYSTEM 5.5 WATTS PER FOOT, MLV/FWD
	R-G RECESSED 4 x 4 STAKE COLOR LED TROFFER WITH INDIRECT SOURCE 30 WATTS, 0-10V
	L-A LINEAR SURFACE MOUNTED WARM-DIM LED COVE LIGHTING SYSTEM 5.5 WATTS PER FOOT, MLV/FWD
	L-C LINEAR SURFACE MOUNTED WARM-DIM LED MLVWORK LIGHTING SYSTEM 3.6 WATTS PER FOOT, MLV/FWD
	XR-A RECESSED FLANGED RECTILINEAR MULTI-CELL WARM-DIM LED DOWNLIGHT 7 WATTS, 0-10V
	XR-B RECESSED FLANGED SQUARE WARM-DIM 15 WATTS, MLV/FWD
	XR-C RECESSED FLANGED RECTILINEAR MULTI-CELL WARM-DIM LED DOWNLIGHT 7 WATTS, 0-10V
	XL-A LINEAR SURFACE MOUNTED WARM-DIM LED LIGHTING SYSTEM (WET LOCATION) 3.6 WATTS PER FOOT, MLV/FWD
	XL-C LINEAR SURFACE MOUNTED WARM-DIM LED FACADE LIGHTING SYSTEM (WET LOCATION) 3.6 WATTS PER FOOT, MLV/FWD
	XS-A STAKE MOUNTED LED PLANT UPLIGHT (WET LOCATION) 7.5 WATTS, MLV/FWD
	XS-B TRELLIS MOUNTED LED ADJUSTABLE ACCENT (WET LOCATION) 8 WATTS, MLV/FWD
	XS-C SURFACE MOUNTED STATIC COLOR LED ARCHITECTURAL UPLIGHT (WET LOCATION) 16.5 WATTS, 0-10V
	XS-D EXTERIOR DECORATIVE WALL SCONCE
	ID - DECORATIVE PENDANTS (REFER TO FFE SPEC)
	R-A RECESSED FLANGED SQUARE LED DOWNLIGHT 13 WATTS, MLV/FWD
	R-B RECESSED FLANGED SQUARE LED WALL WASHER 13 WATTS, MLV/FWD
	ID - SURFACE MOUNTED ARCHITECTURAL UPDOWN WALL SCONCE (REFERENCE FFE SPEC)
	EXHAUST FAN

CEILING LEGEND:	
	C - CEILING FINISH
	8'-6" - CEILING HEIGHT
	A - PRIMED & PAINTED GYPSUM BOARD
	B - PRIMED & PAINTED GYPSUM BOARD - MOISTURE RESISTANT
	C - GYPBD ON 1/2" RESILIENT CHANNELS APPLIED TO UNDERSIDE OF FLOOR / ROOF SYSTEM ABOVE. PAINT FINISH - ELEVATION INDICATED MAY BE "APPROXIMATE" & FOR GENERAL REFERENCE ONLY - REFER TO SECTIONS
	D - <NOT USED>
	E - 2X2 LAY-IN CLG. GRID SYSTEM SUSPENDED FROM STRUCT. - BASIS OF DESIGN: ARMSTRONG DUNE REGULAR CLG. TILE W/ 9/16" GRID
	F - <NOT USED>
	G - FIBER CEMENT PANEL SOFFIT
	H - WOOD-LOOK FIBER CEMENT PANELS
	J - PRE-FINISHED WOOD VENEER WALL COVERING
	K - ENGINEERED WOOD STRUCTURAL SYSTEM

KEY NOTES	
1	LAUNDRY CHUTE - SHAFT OPEN TO VENT AT ROOF
2	4TH FLOOR ROOF HATCH, SIZE PER LOCAL BUILDING CODES, ACCESSED VIA AN ALTERNATING TREAD STAIR
3	TRELLIS AT GRILL ZONE
4	CENTER BEAM OF ACCENT CEILING WITH CENTER OF DOOR OPENING AT VESTIBULE
5	SUSPENDED CEILING GRID AND LIGHTING SYSTEM
6	BACK LIT AMENITY SIGNAGE ON STANDOFFS
7	REFERENCE BUILDING SECTIONS FOR HEIGHT CLEARANCES
8	LOCATE DIMMER/LIGHTING CONTROL PANEL WITHIN BACK OF HOUSE OFFICE FOR ALL OF CENTRAL HUB
9	COORDINATE BLOCKING REQUIREMENTS IN CEILING WITH WALL PANEL MANUFACTURER'S SPECIFICATIONS (FLOOR TO CEILING OPTION ONLY)

GENERAL NOTES:	
1.	AIR HANDLING EQUIPMENT LOCATIONS ARE APPROXIMATE - FINAL LOCATIONS TO BE DETERMINED BY DESIGNER OF RECORD.
2.	TYP. GUEST ROOM FLOOR CORRIDOR CEILING HEIGHTS ARE MINIMUM.
3.	REFER TO GUEST ROOM CEILING PLANS FOR ADDITIONAL LIGHTING INFORMATION.
4.	ELECTRICAL AND MECHANICAL FIXTURE LOCATIONS ARE SHOWN ONLY AS A BASIS FOR DESIGN. FINAL DESIGN TO BE DETERMINED BY DESIGNER OF RECORD AND MUST MEET ALL HOMEWOOD STANDARDS.
5.	NOT USED
6.	BOTH AUDIBLE AND VISIBLE FIRE ALARM DEVICES SHALL BE PROVIDED IN PUBLIC AND COMMON AREAS, AND GUEST ROOMS DESIGNED TO HAVE MOBILITY FEATURES. THE SYSTEM MUST BE DESIGNED TO BE ABLE TO BE INTEGRATED INTO EMPLOYEE WORK SPACES AND MUST COMPLY WITH NFPA 72 AND STATE, LOCAL AND FEDERAL REGULATIONS. DEVICES MUST BE LOCATED SO THE LIGHT IS VISIBLE IN EACH REQUIRED SPACE.
7.	FLOOR IMMEDIATELY ABOVE THE COMPLETECOM ROOM MUST BE WATERTIGHT AND ANY OPENINGS IN THE CEILING, WALLS OR FLOORS MUST BE SEALED.

 Holyfield Construction, Inc.
2371 Tower Drive, Monroe, LA 71201


Lonnie E. Patrick
ARCHITECT
1000 PRENTICE PARKWAY ROAD
DOWNSVILLE, LOUISIANA 71234
Ph: 504.337.4001
Fax: 504.337.4001


Expires: 12-1-2026
4-14-2026

New Construction for
HOMWOOD Suites by Hilton
310 THOMAS ROAD
WEST MONROE, LOUISIANA 71291

PROJECT NO.
23-670ND / 60816

REVISIONS

02-20-26

CEILING PLAN - FIRST FLR

SHEET NO.
A-120
CONSTRUCTION DOCUMENTS

\\holyfield.local\Shared\Users\Patrick\Documents\Build\prop. Thomas Road-Monroe - ARCH - V2 - HWS - BldgRev - LEP\ArchA121

LIGHT FIXTURE LEGEND:	
	2X2 LIGHT FIXTURE
	2X4 LIGHT FIXTURE
	SURFACE MOUNTED LIGHT FIXTURE
	XR-A RECESSED FLANGED RECTILINEAR MULTI-CELL WARM-DIM LED DOWNLIGHT 7 WATTS, 0-10V
	XR-B RECESSED FLANGED SQUARE WARM-DIM 15 WATTS, MLV/FWD
	XR-C RECESSED FLANGED RECTILINEAR MULTI-CELL WARM-DIM LED DOWNLIGHT 7 WATTS, 0-10V
	R-F RECESSED LINEAR LED WARM-DIM LED WALL WASH SYSTEM 5.5 WATTS PER FOOT, MLV/FWD
	R-G RECESSED 4 x 4 STATIC COLOR LED TROFFER WITH INDIRECT SOURCE 30 WATTS, 0-10V
	L-A LINEAR SURFACE MOUNTED WARM-DIM LED COVE LIGHTING SYSTEM 5.5 WATTS PER FOOT, MLV/FWD
	L-C LINEAR SURFACE MOUNTED WARM-DIM LED MILLWORK LIGHTING SYSTEM 3.6 WATTS PER FOOT, MLV/FWD
	XS-D EXTERIOR DECORATIVE WALL SCONCE
	ID - DECORATIVE PENDANTS (REFER TO FFE SPECS)
	R-A RECESSED FLANGED SQUARE LED DOWNLIGHT 13 WATTS, MLV/FWD
	R-B RECESSED FLANGED SQUARE LED WALL WASHER 13 WATTS, MLV/FWD
	ID - SURFACE MOUNTED ARCHITECTURAL UPDOWN WALL SCONCE (REFERENCE FFE SPEC)
	EXHAUST FAN



Paint Gypsum Board Ceiling
Paint Gypsum Board Ceiling
Paint on MR Gypsum Board Ceiling
Paint on MR Gypsum Board Ceiling

12893.6 SQ FT
13638.9 SQ FT
1228.5 SQ FT
1065.2 SQ FT

CEILING LEGEND:	
	CEILING FINISH CEILING HEIGHT
A.	PRIMED & PAINTED GYPSUM BOARD
B.	PRIMED & PAINTED GYPSUM BOARD - MOISTURE RESISTANT
C.	GYPSUM ON 1/2\"/>
D.	<NOT USED>
E.	2X2 LAY-IN CLG. GRID SYSTEM SUSPENDED FROM STRUCT. - BASIS OF DESIGN ARMSTRONG DUNE TEGULAR CLG. TILE W/ 9/16\"/>
F.	<NOT USED>
G.	FIBER CEMENT PANEL SOFFIT
H.	WOOD-LOOK FIBER CEMENT PANELS
J.	PRE-FINISHED WOOD VENEER WALL COVERING
K.	ENGINEERED WOOD STRUCTURAL SYSTEM

KEY NOTES	
1	LAUNDRY CHUTE - SHAFT OPEN TO VENT AT ROOF
2	4TH FLOOR ROOF HATCH, SIZE PER LOCAL BUILDING CODES, ACCESSED VIA AN ALTERNATING TREAD STAIR
3	TRELLIS AT GRILL ZONE
4	CENTER SEAM OF ACCENT CEILING WITH CENTER OF DOOR OPENING AT VESTIBULE
5	SUSPENDED CEILING GRID AND LIGHTING SYSTEM
6	BACK LIT AMENITY SIGNAGE ON STANDOFFS
7	REFERENCE BUILDING SECTIONS FOR HEIGHT CLEARANCES
8	LOCATE DIMMER/ LIGHTING CONTROL PANEL WITHIN BACK OF HOUSE OFFICE FOR ALL OF CENTRAL HUB
9	COORDINATE BLOCKING REQUIREMENTS IN CEILING WITH WALL PANEL MANF.'S SPECIFICATIONS (FLOOR TO CEILING OPTION ONLY)

GENERAL NOTES:	
1.	AIR HANDLING EQUIPMENT LOCATIONS ARE APPROXIMATE - FINAL LOCATIONS TO BE DETERMINED BY DESIGNER OF RECORD.
2.	TYP. GUEST ROOM FLOOR CORRIDOR CEILING HEIGHTS ARE MINIMUMS.
3.	REFER TO GUEST ROOM CEILING PLANS FOR ADDITIONAL LIGHTING INFORMATION.
4.	ELECTRICAL AND MECHANICAL FIXTURE LOCATIONS ARE SHOWN ONLY AS A BASIS FOR DESIGN. FINAL DESIGN TO BE DETERMINED BY DESIGNER OF RECORD AND MUST MEET ALL HOMEWOOD STANDARDS.
5.	NOT USED
6.	BOTH AUDIBLE AND VISIBLE FIRE ALARM DEVICES SHALL BE PROVIDED IN PUBLIC AND COMMON AREAS, AND GUEST ROOMS DESIGNED TO HAVE MOBILITY FEATURES. THE SYSTEM MUST BE DESIGNED TO BE ABLE TO BE INTEGRATED INTO EMPLOYEE WORK SPACES AND MUST COMPLY WITH NFPA 72 AND STATE, LOCAL AND FEDERAL REGULATIONS. DEVICES MUST BE LOCATED SO THE LIGHT IS VISIBLE IN EACH REQUIRED SPACE.
7.	FLOOR IMMEDIATELY ABOVE THE COMPTHECOM ROOM MUST BE WATERTIGHT AND ANY OPENINGS IN THE CEILING, WALLS OR FLOORS MUST BE SEALED.

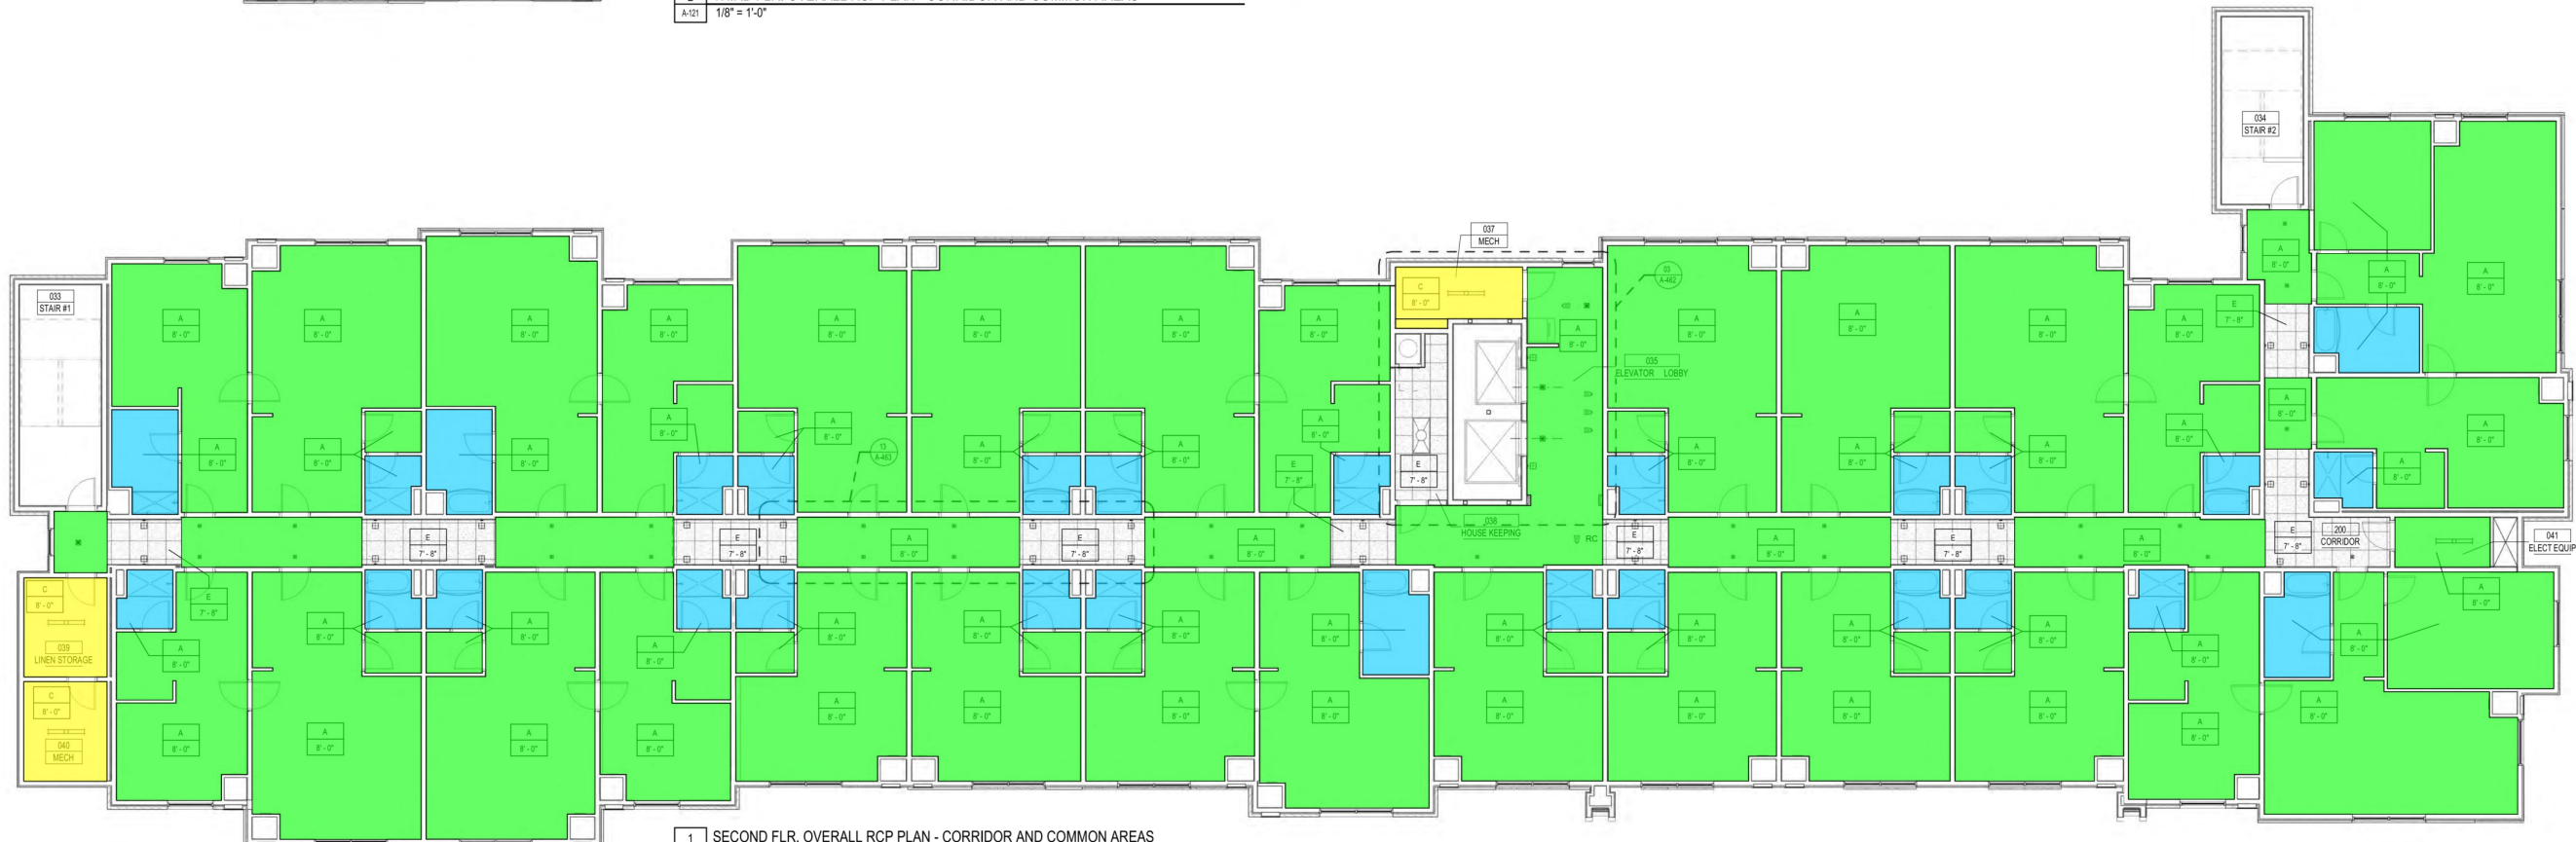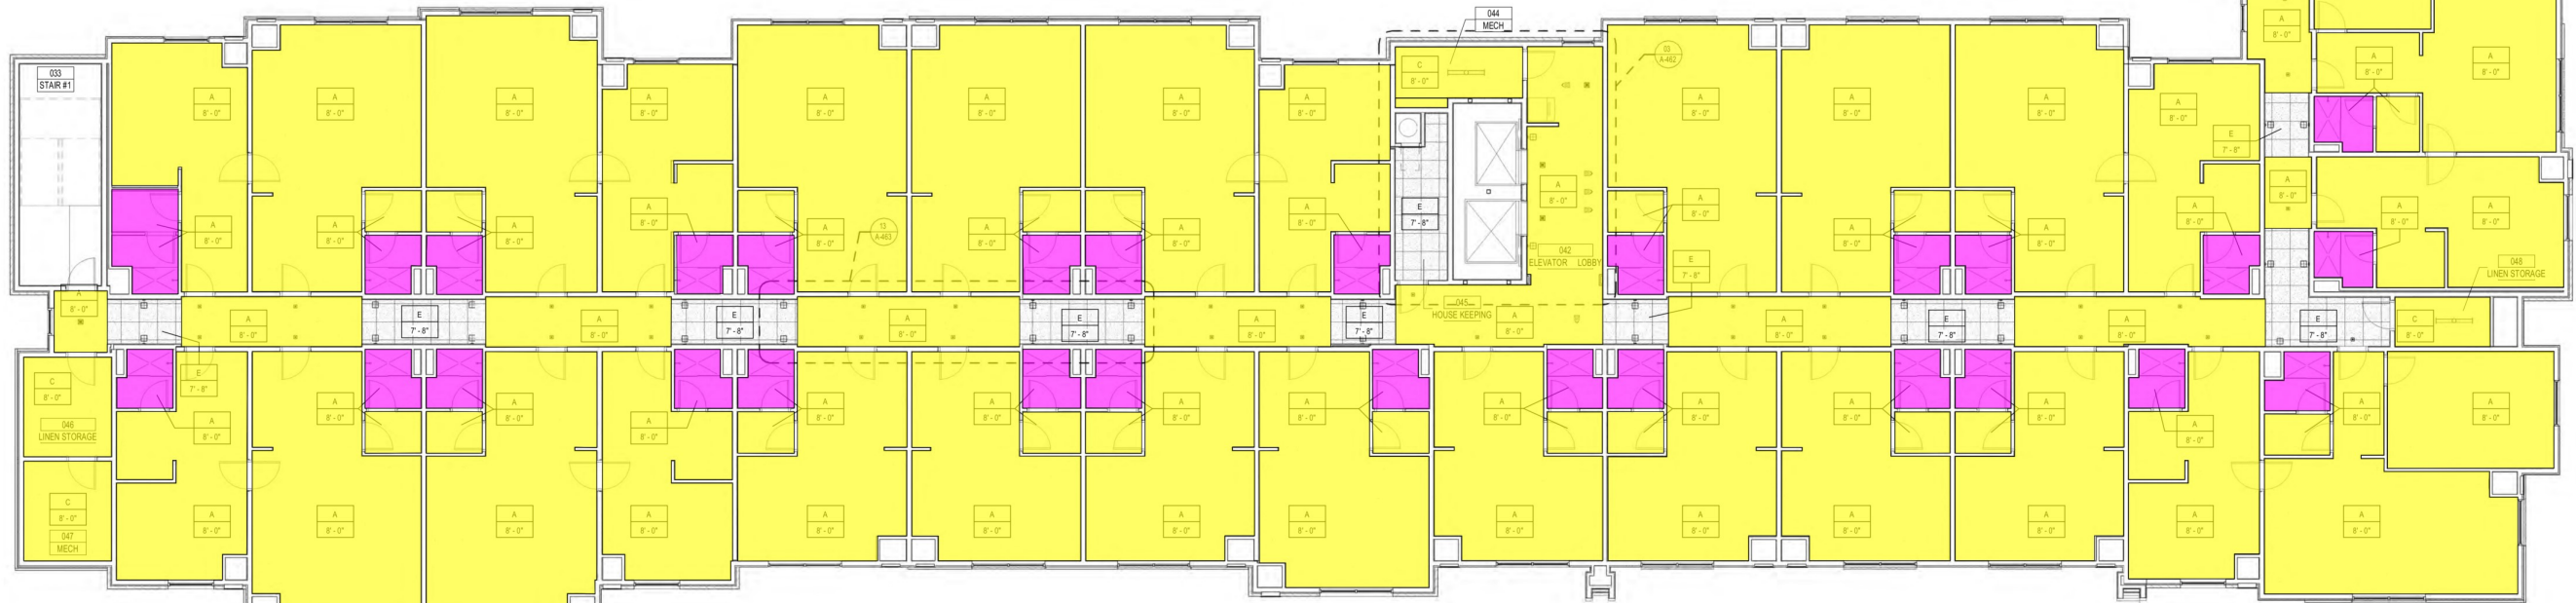

Holyfield Construction, Inc.

2271 Tower Drive, Monroe, LA 71201

Lonnie E. Patrick
ARCHITECT

1000 PRENTICE PARQUE ROAD
DOWNSVILLE, LOUISIANA 71234

LA Reg No. 8911
If a document does not bear the architect's seal and signature, it is invalid and may not be used for regulatory or legal purposes.

Expires: 12-1-2026

HOMEWOOD
SUITES by Hilton

755 CROSSOVER LN., MEMPHIS TN 38117
P. 901.374.5000 F. 901.374.5800

New Construction for
HOMEWOOD Suites by Hilton

310 THOMAS ROAD
WEST MONROE, LOUISIANA 71291

PROJECT NO.
23-67ND / 60816

REVISIONS

02-20-26

CEILING PLAN -
SECOND &
THIRD FLR.
OVERALL

SHEET NO.
A-121

CONSTRUCTION
DOCUMENTS

\\holyfield.local\Shared\Users\Patrick\Documents\Paal prop. Thomas-Road-Monroe - ARCH - V2 - HWS - BldgRev - LEPatrickA12.rvt



- Paint Gypsum Board Ceiling
- Paint on MR Gypsum Board Ceiling

13796.8 SQ FT
1026.2 SQ FT

LIGHT FIXTURE LEGEND:

	2X2 LIGHT FIXTURE		XR-A RECESSED FLANGED RECTILINEAR MULTI-CELL WARM-DIM LED DOWNLIGHT 7 WATTS, 0-10V
	2X4 LIGHT FIXTURE		XR-B RECESSED FLANGED SQUARE WARM-DIM LED DOWNLIGHT 15 WATTS, MLVFWO
	SURFACE MOUNTED LIGHT FIXTURE		XR-C RECESSED FLANGED RECTILINEAR MULTI-CELL WARM-DIM LED DOWNLIGHT 7 WATTS, 0-10V
	WALL MOUNTED LIGHT FIXTURE		XL-A LINEAR SURFACE MOUNTED WARM-DIM LED LIGHTING SYSTEM (WET LOCATION) 3.6 WATTS PER FOOT, MLVFWO
	R-A RECESSED FLANGED SQUARE WARM-DIM LED ADJUSTABLE 15 WATTS, MLVFWO		XL-C LINEAR SURFACE MOUNTED WARM-DIM LED FACADE LIGHTING SYSTEM (WET LOCATION) 3.6 WATTS PER FOOT, MLVFWO
	R-B RECESSED FLANGED SQUARE WARM-DIM LED ADJUSTABLE 15 WATTS, MLVFWO		XS-A STAKE MOUNTED LED PLANT UPLIGHT (WET LOCATION) 7.5 WATTS, MLVFWO
	R-C RECESSED FLANGED SQUARE WARM-DIM LED WALL WASHER 15 WATTS, MLVFWO		XS-B TRELLIS MOUNTED LED ADJUSTABLE ACCENT (WET LOCATION) 8 WATTS, MLVFWO
	R-D RECESSED RECTILINEAR WARM-DIM FLANGED DOWNLIGHT FIXTURE WITH 4000K BEAM SPREAD 7 WATTS, 0-10V		XS-C SURFACE MOUNTED STATIC COLOR LED ARCHITECTURAL UPLIGHT (WET LOCATION) 16.5 WATTS, 0-10V
	R-E RECESSED FLANGE SQUARE WARM-DIM LED DOWNLIGHT WITH LUMINOUS LENS 12 WATTS, MLVFWO		S-D EXTERIOR DECORATIVE WALL SCONCE
	R-F RECESSED LINEAR LED WARM-DIM LED WALL WASH SYSTEM 5.5 WATTS PER FOOT, MLVFWO		ID DECORATIVE PENDANTS (REFER TO FFE SPECS)
	R-G RECESSED 4 x 4 STATIC COLOR LED TROFFER WITH INDIRECT SOURCE 30 WATTS, 0-10V		R-A RECESSED FLANGED SQUARE LED DOWNLIGHT 13 WATTS, MLVFWO
	L-A LINEAR SURFACE MOUNTED WARM-DIM LED COVE LIGHTING SYSTEM 5.5 WATTS PER FOOT, MLVFWO		R-B RECESSED FLANGED SQUARE LED WALL WASHER 13 WATTS, MLVFWO
	L-C LINEAR SURFACE MOUNTED WARM-DIM LED MILLWORK LIGHTING SYSTEM 3.6 WATTS PER FOOT, MLVFWO		ID SURFACE MOUNTED ARCHITECTURAL UP/DOWN WALL SCONCE (REFERENCE FFE SPEC)
			EXHAUST FAN

KEY NOTES

- LAUNDRY CHUTE - SHAFT OPEN TO VENT AT ROOF
- 4TH FLOOR ROOF HATCH, SIZE PER LOCAL BUILDING CODES, ACCESSED VIA AN ALTERNATING TREAD STAIR
- TRELLIS AT GRILL ZONE
- CENTER SEAM OF ACCENT CEILING WITH CENTER OF DOOR OPENING AT VESTIBULE
- SUSPENDED CEILING GRID AND LIGHTING SYSTEM
- BACK LIT AMENITY SIGNAGE ON STANDOFFS
- REFERENCE BUILDING SECTIONS FOR HEIGHT CLEARANCES
- LOCATE DIMMER/ LIGHTING CONTROL PANEL WITHIN BACK OF HOUSE OFFICE FOR ALL OF CENTRAL HUB.
- COORDINATE BLOCKING REQUIREMENTS IN CEILING WITH WALL PANEL MANF.'S SPECIFICATIONS (FLOOR TO CEILING OPTION ONLY)


CEILING LEGEND:

C	8'-6"		
A	PRIMED & PAINTED GYPSUM BOARD		
B	PRIMED & PAINTED GYPSUM BOARD - MOISTURE RESISTANT		
C	GYPSUM ON 1/2" RESILIENT CHANNELS APPLIED TO UNDERSIDE OF FLOOR / ROOF SYSTEM ABOVE. PAINT FINISH - ELEVATION INDICATED MAY BE "APPROXIMATE" & FOR GENERAL REFERENCE ONLY - REFER TO SECTIONS		
D	<NOT USED>		
E	2X2 LAY-IN CLG. GRID SYSTEM SUSPENDED FROM STRUCT. - BASIS OF DESIGN ARMSTRONG DUNE REGULAR CLG. TILE W/ 9/16" GRID		
F	<NOT USED>		
G	FIBER CEMENT PANEL SOFFIT		
H	WOOD-LOOK FIBER CEMENT PANELS		
J	PRE-FINISHED WOOD VENEER WALL COVERING		
K	ENGINEERED WOOD STRUCTURAL SYSTEM		

GENERAL NOTES:

- AIR HANDLING EQUIPMENT LOCATIONS ARE APPROXIMATE - FINAL LOCATIONS TO BE DETERMINED BY DESIGNER OF RECORD.
- TYP. GUEST ROOM FLOOR CORRIDOR CEILING HEIGHTS ARE MINIMUMS.
- REFER TO GUEST ROOM CEILING PLANS FOR ADDITIONAL LIGHTING INFORMATION.
- ELECTRICAL AND MECHANICAL FIXTURE LOCATIONS ARE SHOWN ONLY AS A BASIS FOR DESIGN. FINAL DESIGN TO BE DETERMINED BY DESIGNER OF RECORD AND MUST MEET ALL HOMEWOOD STANDARDS.
- NOT USED
- BOTH AUDIBLE AND VISIBLE FIRE ALARM DEVICES SHALL BE PROVIDED IN PUBLIC AND COMMON AREAS, AND GUEST ROOMS DESIGNED TO HAVE MOBILITY FEATURES. THE SYSTEM MUST BE DESIGNED TO BE ABLE TO BE INTEGRATED INTO EMPLOYEE WORK SPACES AND MUST COMPLY WITH NFPA 72 AND STATE, LOCAL AND FEDERAL REGULATIONS. DEVICES MUST BE LOCATED SO THE LIGHT IS VISIBLE IN EACH REQUIRED SPACE.
- FLOOR IMMEDIATELY ABOVE THE COMPTTELECOM ROOM MUST BE WATER-TIGHT AND ANY OPENINGS IN THE CEILING, WALLS OR FLOORS MUST BE SEALED.

 Holyfield Construction, Inc.
2271 Tower Drive, Monroe, LA 71201



Lonnie E. Patrick
ARCHITECT
1000 PRENTICE PARQUE ROAD
DOWNSVILLE, LOUISIANA 71234
Ph: 225-274-4001
Lonnie@holyfieldinc.com



HOMEWOOD
SUITES by Hilton
755 CROSSOVER LN., MEMPHIS TN 38117
P: 901.374.5000
F: 901.374.5800

New Construction for
HOMEWOOD Suites by Hilton
310 THOMAS ROAD
WEST MONROE, LOUISIANA 71291

PROJECT NO.
23-670ND / 60816

REVISIONS

02-20-26

CEILING FLR.
FOURTH FLR.
OVERALL

SHEET NO.
A-122
CONSTRUCTION
DOCUMENTS

