


The logo for PDG Engineering, featuring the letters "PDG" in a large, bold, stylized font, with a horizontal line underneath, and the word "ENGINEERING" in a smaller, sans-serif font below the line.

PDG ENGINEERING, LLC

(318) 535-8110
chad.parks@des-plus.com

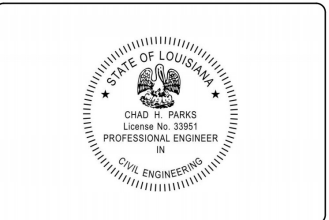

THESE DRAWINGS, SPECIFICATIONS, AND OTHER DOCUMENTS PREPARED BY DESIGN PLUS CONSULTING ENGINEERS ARE FOR USE SOLELY WITH RESPECT TO THIS PROJECT AND, UNLESS OTHERWISE PROVIDED, THE ENGINEER SHALL BE DEEMED THE AUTHOR OF THESE DOCUMENTS AND SHALL RESERVE ALL RIGHTS, INCLUDING REPRODUCIBLE COPIES OF THE ENGINEERS' DRAWINGS, SPECIFICATIONS AND OTHER DOCUMENTS. THE ENGINEERS' DRAWINGS, SPECIFICATIONS OR OTHER DOCUMENTS SHALL NOT BE USED BY THE OWNER, OR BY OTHERS, ON OTHER PROJECTS, EXCEPT BY AGREEMENT IN WRITING AND WITH APPROPRIATE COMPENSATION TO THE ENGINEER.

Sheet #	Sheet Name	Revision
GENERAL		
G000	Cover Sheet	
G001	Standard Symbols, Details, Abbreviations	
G002	Fire Life Safety Plan	
G003	UL Details	
CIVIL		
C000	Site/Civil Standard Specifications	
C001	Water Standard Specifications	
C002	Sewer Standard Specifications	
C100	Existing Site	
C300	Site Development	
STRUCTURAL		
S000	Structural Standard Specifications	
S100	Foundation Layout	
ARCHITECTURE		
A000	Architectural Standard Specifications	
A001	Architectural Standard Specifications	
A100	Floor Plan - Coordination Plan	
A101	Floor Plan Dimensions, Wall Callout	
A102	Roof Plan	
A200	Exterior Elevations	
A201	Exterior Elevations	
A300	Building Section	
A400	Wall Section	
A401	Section Details	
A500	Isometric View	
A501	Perspective View	
A600	Enlarged Plan, Interior Elevations	
A601	Enlarged Plan, Interior Elevations	
A602	Millwork Sections	
A700	Reflected Ceiling Plan	
A701	Floor Finish Plan	
A800	Door / Win. Schedule, Room Finish Schedule	
PLUMBING		
P000	Notes & Symbols	
P101	Plumbing Fixture Schedule	

Sheet #	Sheet Name	Revision
GENERAL		
G000	Cover Sheet	
G001	Standard Symbols, Details, Abbreviations	
G002	Fire Life Safety Plan	
G003	UL Details	
CIVIL		
C000	Site/Civil Standard Specifications	
C001	Water Standard Specifications	
C002	Sewer Standard Specifications	
C100	Existing Site	
C300	Site Development	
STRUCTURAL		
S000	Structural Standard Specifications	
S100	Foundation Layout	
ARCHITECTURE		
A000	Architectural Standard Specifications	
A001	Architectural Standard Specifications	
A100	Floor Plan - Coordination Plan	
A101	Floor Plan Dimensions, Wall Callout	
A102	Roof Plan	
A200	Exterior Elevations	
A201	Exterior Elevations	
A300	Building Section	
A400	Wall Section	
A401	Section Details	
A500	Isometric View	
A501	Perspective View	
A600	Enlarged Plan, Interior Elevations	
A601	Enlarged Plan, Interior Elevations	
A602	Millwork Sections	
A700	Reflected Ceiling Plan	
A701	Floor Finish Plan	
A800	Door / Win. Schedule, Room Finish Schedule	
PLUMBING		
P000	Notes & Symbols	
P101	Plumbing Fixture Schedule	

[illegible]

BEFORE ANY WORK BEGINS, THE CONTRACTOR SHALL EXAMINE THE DRAWINGS, MAPS, AND EXISTING SITE TO DETERMINE THE EXACT LOCATION OF UTILITIES. THE CONTRACTOR SHALL VERIFY THE LOCATION AND SIZE OF SHOWN UTILITIES. THE CONTRACTOR SHALL CONTACT LOUISIANA ONE CALL PRIOR TO ANY CONSTRUCTION ACTIVITIES - 811

IF DURING CONSTRUCTION ACTIVITIES, UNKNOWN SERVICES ARE DISCOVERED, THE CONTRACTOR SHALL IMMEDIATELY NOTIFY THE OWNER AND SUSPECTED UTILITY.

Cover Sheet

Project number	25103
Date	03.19.26
Drawn by	CHP
Checked by	CHP
Sheet Number	G000
Scale	

An architectural rendering of a single-story building with a gabled roof. The building features a covered entrance supported by two square columns. The entrance area has a brick base, while the rest of the building has horizontal siding. A sign with a compass rose logo and the text "PATHFINDER RECOVERY" is mounted on the gable end. The building has several windows along its side and a long, low profile.

PO BOX 81
CROWVILLE, LA 71230

(318) 535-8110
chad.parks@des-plus.com



THESE DRAWINGS, SPECIFICATIONS, AND OTHER DOCUMENTS PREPARED BY DESIGN PLUS CONSULTING ENGINEERS ARE FOR USE SOLELY WITH RESPECT TO THIS PROJECT AND, UNLESS OTHERWISE PROVIDED, THE ENGINEER SHALL BE DEEMED THE AUTHOR OF THESE DOCUMENTS AND SHALL RESERVE ALL RIGHTS, INCLUDING REPRODUCIBLE COPIES OF THE ENGINEERS DRAWINGS, SPECIFICATIONS AND OTHER DOCUMENTS. THE ENGINEERS DRAWINGS, SPECIFICATIONS OR OTHER DOCUMENTS SHALL NOT BE USED BY THE OWNER, OR BY OTHERS, ON OTHER PROJECTS, EXCEPT BY AGREEMENT IN WRITING AND WITH APPROPRIATE COMPENSATION TO THE ENGINEER.

[illegible]

BEFORE ANY WORK BEGINS, THE CONTRACTOR SHALL EXAMINE THE DRAWINGS, MAPS, AND EXISTING SITE TO DETERMINE THE EXACT LOCATION OF UTILITIES. THE CONTRACTOR SHALL VERIFY THE LOCATION AND SIZE OF SHOWN UTILITIES. THE CONTRACTOR SHALL CONTACT LOUISIANA ONE CALL PRIOR TO ANY CONSTRUCTION ACTIVITIES - 811

IF DURING CONSTRUCTION ACTIVITIES, UNKNOWN SERVICES ARE DISCOVERED, THE CONTRACTOR SHALL IMMEDIATELY NOTIFY THE OWNER AND SUSPECTED UTILITY.

PATHFINDER
RECOVERY CENTER

Reflected Ceiling Plan

Project number	25103
Date	03.19.26
Drawn by	CHP
Checked by	CHP
Sheet Number	A700
Scale	As indicated

1. PRIOR TO CONSTRUCTION OF THE PROJECT CEILINGS, THE CONTRACTOR SHALL COORDINATE AND VERIFY THE LOCATION OF LIGHTING FIXTURES AND CEILING DEVICES WITH THE OWNERS FURNITURE AND EQUIPMENT PLAN. THE CONTRACTORS SHALL REVIEW THIS INFORMATION AND BRING ANY SUSPECTED DISCREPANCIES TO THE ATTENTION OF THE OWNERS REPRESENTATIVE FOR RESOLUTION PRIOR TO CONSTRUCTION.
2. CONTRACTOR SHALL COORDINATE POWER AND DATA LOCATIONS WITH FURNITURE AND ELECTRICAL CONTRACTORS.
3. ALL CEILING HEIGHTS CORRESPOND TO RESPECTIVE FINISH FLOOR/ELEVATION LEVEL.
4. CENTER DEVICES INCLUDING DOWNLIGHTS, SPRINKLER HEADS, HVAC GRILLES SMALLER THAN 2 BY 2 FEET, IN CEILING TILE UNLESS NOTED OTHERWISE.
5. REFER TO ELECTRICAL DRAWINGS FOR LIGHT FIXTURE LOCATIONS IN ROOMS WHICH REQUIRE COORDINATION OF EQUIPMENT AND DUCTWORK.
6. CENTER EXIT SIGNS OVER DOORS UNLESS NOTED OTHERWISE .
7. CENTER CEILING SYSTEMS IN ROOMS BOTH DIRECTIONS UNLESS NOTED OTHERWISE .
8. ADJACENT FACE OF SOFFIT WITH FACE OF PARTITION, TYPICAL.
9. SEE MECHANICAL, ELECTRICAL, AND EQUIPMENT DRAWINGS FOR CEILING FIXTURE SYMBOLOLOGY.
10. PATCH EXISTING CEILINGS DISTURBED BY INSTALLATION OF PLUMBING, MECHANICAL, OR ELECTRICAL INFRASTRUCTURE TO MATCH EXISTING OR REPLACED.
11. ACOUSTIC CEILING PANELS TO BE POSITIONED AS SHOWN WITH A MINIMUM CEILING PANEL TO BE 6" WIDE. WHERE THIS IS NOT POSSIBLE, CONTRACTOR TO CONSULT P.M.E. ENGINEER FOR CLARIFICATION.
12. REFLECTED CEILING PLAN PROVIDED FOR REFERENCE ONLY. COORDINATE ALL WORK SHOWN WITH STRUCTURAL, MECHANICAL, & ELECTRICAL DRAWINGS. REFER TO MECH. & ELECTRICAL DRAWINGS FOR SPECIFIC LOCATION AND LAYOUTS.


6438.8 SQ FT

420.5 SQ FT

116.3 SQ FT

 		<u>DESCRIPTION</u>
 		INDICATES 2' X 2' SUSPENDED ACOUSTICAL GRID CEILING
 		INDICATES SUSPENDED GYPSUM BOARD CEILING
 		INDICATES EXPOSED CONSTRUCTION NO CEILING

- Paint On Gypsum Board Ceiling
- Paint On MR Gypsum Board Ceiling
- Paint On Exposed Structure

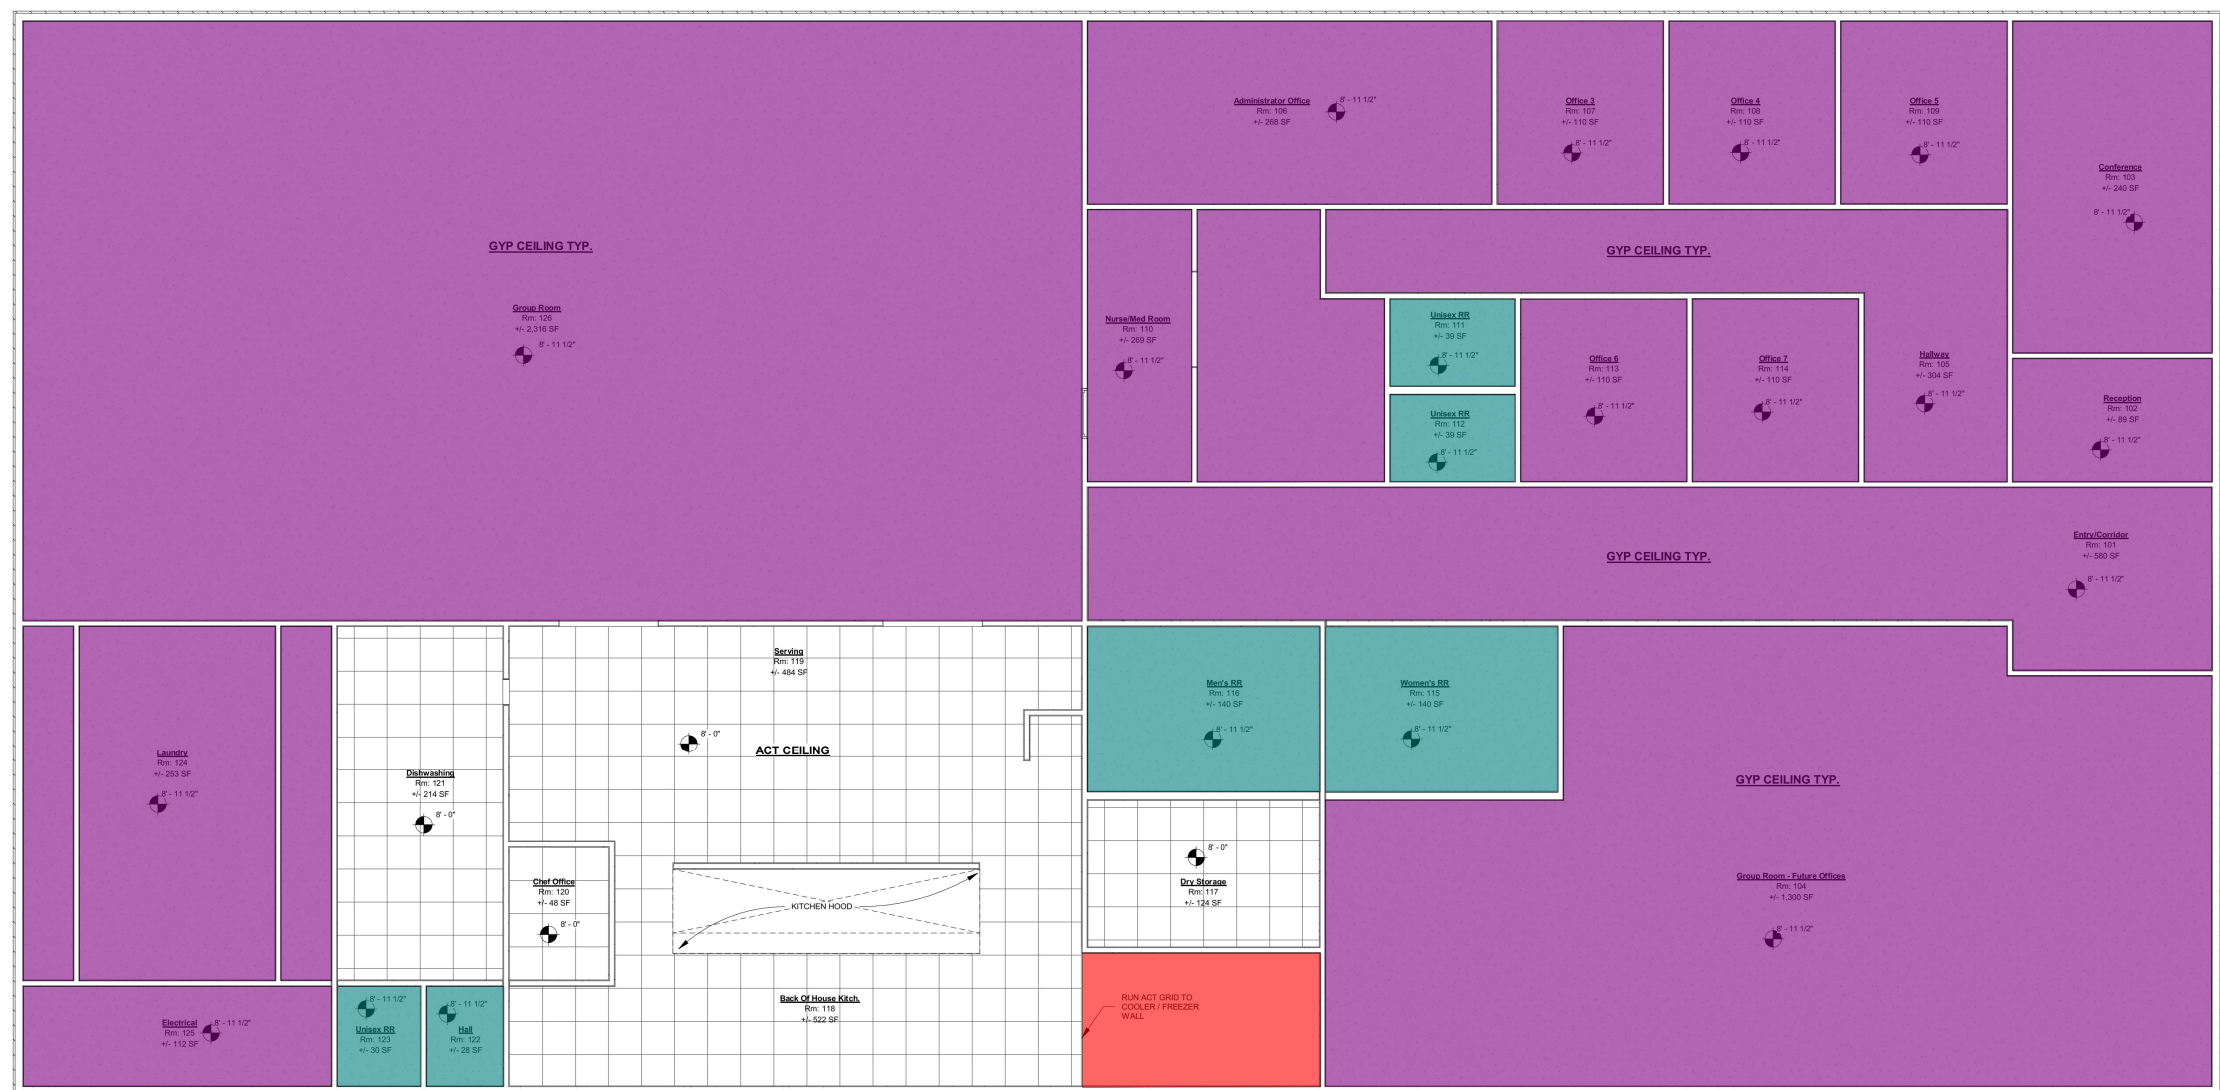

① 1st Flr RCP
3/16" = 1'-0"



ROOM FINISH ABBREVIATIONS:

WD	-	WOOD PLANK
TC	-	TILE CARPET
IB	-	INTEGRAL BASE
PC	-	POLISHED CONCRETE
PG	-	PAINTED GYPSUM
ACT	-	ACOUSTICAL CEILING TILE
RCB	-	RUBBER COVE BASE
LVT	-	LAMINATE VENEER TILE
SLF	-	SELF-LEVELING POURED FLOOR


Room Finish Schedule						
Number	Name	Area	Floor Finish	Wall Finish	Ceiling Finish	Base Finish
101	Entry/Corridor	580 SF	WD LVT	PG	PG	RCB
102	Reception	89 SF	WD LVT	PG	PG	RCB
103	Conference	240 SF	WD LVT	PG	PG	RCB
104	Group Room - Future Offices	1,300 SF	TC	PG	PG	RCB
105	Hallway	304 SF	WD LVT	PG	PG	RCB
106	Administrator Office	268 SF	TC	PG	PG	RCB
107	Office 3	110 SF	TC	PG	PG	RCB
108	Office 4	110 SF	TC	PG	PG	RCB
109	Office 5	110 SF	TC	PG	PG	RCB
110	Nurse/Med Room	269 SF	PC	PG	PG	RCB
111	Unisex RR	39 SF	PC	WT / PG	PG	RCB
112	Unisex RR	39 SF	PC	WT / PG	PG	RCB
113	Unisex RR	110 SF	TC	PG	PG	RCB
114	Unisex RR	110 SF	TC	PG	PG	RCB
115	Unisex RR	140 SF	PC	WT / PG	PG	RCB
116	Unisex RR	140 SF	PC	WT / PG	PG	RCB
117	Back of House Kitchen	124 SF	SLF	WT / PG	ACT	IB
118	Back of House Kitchen	522 SF	SLF	WT / PG	ACT	IB
119	Serving	484 SF	SLF	WT / PG	ACT	IB
120	Chef Office	48 SF	SLF	PG	ACT	IB
121	Dishwashing	214 SF	SLF	WT / PG	ACT	IB
122	Hall	28 SF	SLF	WT / PG	PG	IB
123	Unisex RR	30 SF	SLF	WT / PG	PG	IB
124	Laundry	253 SF	SLF	PG	PG	IB
125	Electrical	112 SF	SC	PG	PG	RCB
126	Group Room	2,316 SF	PC	PG	PG	RCB

NOTE:
CONTRACTOR TO ALLOW \$25/YD
MATERIAL ALLOWANCE FOR
CARPET TILES

**ALL TRANSITION TO BE LESS
THAN 1/4" IN HEIGHT.
SUBMITT TRANSITION STRIP
TO OWNER / ARCHITECT FOR
APPROVAL**



1 FLOOR FINISH PLAN
3/16" = 1'-0"

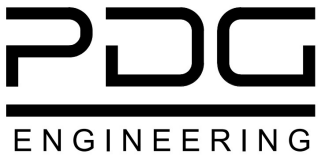

PDG ENGINEERING, LLC

PO BOX 81
CROWVILLE, LA 71230

(318) 535-8110
chad.parks@des-plus.com



THESE DRAWINGS, SPECIFICATIONS, AND OTHER DOCUMENTS PREPARED BY DESIGN PLUS CONSULTING ENGINEERS ARE FOR USE SOLELY WITH RESPECT TO THIS PROJECT AND, UNLESS OTHERWISE PROVIDED, THE ENGINEER SHALL BE DEEMED THE AUTHOR OF THESE DOCUMENTS AND SHALL RESERVE ALL RIGHTS, INCLUDING REPRODUCIBLE COPIES OF THE ENGINEERS' DRAWINGS, SPECIFICATIONS AND OTHER DOCUMENTS. THE ENGINEERS' DRAWINGS, SPECIFICATIONS AND OTHER DOCUMENTS SHALL NOT BE USED BY THE OWNER, OR BY OTHERS, ON OTHER PROJECTS, EXCEPT BY AGREEMENT IN WRITING AND WITH APPROPRIATE COMPENSATION TO THE ENGINEER.

[illegible]

BEFORE ANY WORK BEGINS, THE CONTRACTOR SHALL EXAMINE THE DRAWINGS, MAPS, AND EXISTING SITE TO DETERMINE THE EXACT LOCATION OF UTILITIES. THE CONTRACTOR SHALL VERIFY THE LOCATION AND SIZE OF SHOWN UTILITIES. THE CONTRACTOR SHALL CONTACT LOUISIANA ONE CALL PRIOR TO ANY CONSTRUCTION ACTIVITIES - 811

IF DURING CONSTRUCTION ACTIVITIES, UNKNOWN SERVICES ARE DISCOVERED, THE CONTRACTOR SHALL IMMEDIATELY NOTIFY THE OWNER AND SUSPECTED UTILITY.

PATHFINDER
RECOVERY CENTER

Floor Finish Plan

Project number	25103
Date	03.19.26
Drawn by	CHP
Checked by	CHP
Sheet Number	A701
Scale	3/16" = 1'-0"


PDG
ENGINEERING

PDG ENGINEERING, LLC

(318) 535-8110
chad.parks@des-plus.com


STATE OF LOUISIANA
CHAD LEE PARKS
LICENSE NO. 143952
PROFESSIONAL ENGINEER
CIVIL ENGINEERING

THESE DRAWINGS, SPECIFICATIONS, AND OTHER DOCUMENTS PREPARED BY DESIGN PLUS CONSULTING ENGINEERS ARE FOR USE SOLELY WITH RESPECT TO THIS PROJECT AND, UNLESS OTHERWISE PROVIDED, THE ENGINEER SHALL BE DEEMED THE AUTHOR OF THESE DOCUMENTS AND SHALL RESERVE ALL RIGHTS, INCLUDING REPRODUCIBLE COPIES OF THE ENGINEERS' DRAWINGS, SPECIFICATIONS AND OTHER DOCUMENTS. THE ENGINEERS' DRAWINGS, SPECIFICATIONS OR OTHER DOCUMENTS SHALL NOT BE USED BY THE OWNER, OR BY OTHERS, ON OTHER PROJECTS, EXCEPT BY AGREEMENT IN WRITING AND WITH APPROPRIATE COMPENSATION TO THE ENGINEER.

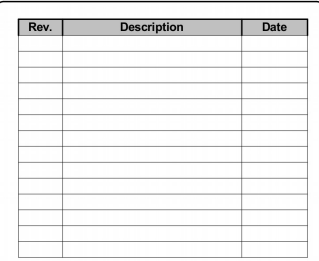

BEFORE ANY WORK BEGINS, THE CONTRACTOR SHALL EXAMINE THE DRAWINGS, MAPS, AND EXISTING SITE TO DETERMINE THE EXACT LOCATION OF UTILITIES. THE CONTRACTOR SHALL VERIFY THE LOCATION AND SIZE OF SHOWN UTILITIES. THE CONTRACTOR SHALL CONTACT LOUISIANA ONE CALL PRIOR TO ANY CONSTRUCTION ACTIVITIES - 811

IF DURING CONSTRUCTION ACTIVITIES, UNKNOWN SERVICES ARE DISCOVERED, THE CONTRACTOR SHALL IMMEDIATELY NOTIFY THE OWNER AND SUSPECTED UTILITY.

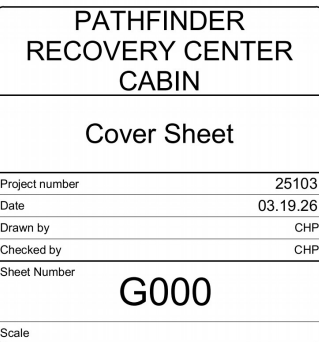

Sheet #	Sheet Name	Revision
GENERAL		
G000	Cover Sheet	
G001	Standard Symbols, Details, Abbreviations	
G001.1	Fire Life Safety Plan	
G002	UL Details	
G003	UL Details	
G004	UL Details	
G005	UL Details	
CIVIL		
C000	Site/Civil Standard Specifications	
C300	Site Development	
STRUCTURAL		
S000	Structural Standard Specifications	
S100	Foundation Layout	
ARCHITECTURE		
A000	Architectural Standard Specifications	
A001	Architectural Standard Specifications	
A100	Floor Plan - Coordination Plan	
A101	FP Dimensioned, Wall Callout, Details, Schedule	
A102	Roof Plan	
A200	Exterior Elevations	
A201	Exterior Elevations	
A300	Building Section	
A400	Section Details	
A500	Isometric View	
A600	Enlarged Plan, Interior Elevations	
A700	Reflected Ceiling Plan	
A800	Door / Win. Schedule, Elevations, Room Finish	
MECHANICAL		
M000	Notes & Symbols	
M101	HVAC Plan	
ELECTRICAL		
E000	Notes & Legends	
E101	Power Plan	
PLUMBING		
P000	Notes & Symbols	
P101	Plumbing Fixture Plan	

FIRE ALARM NOTES

1. SHOP DRAWINGS FOR FIRE ALARM SYSTEM SHALL BE PREPARED AND SUBMITTED FOR REVIEW TO THE ENGINEER AND LOCAL AUTHORITY HAVING JURISDICTION PRIOR TO SYSTEM INSTALLATION
2. FIRE ALARM SYSTEMS SHALL BE INSTALLED, TESTED, AND MAINTAINED IN ACCORDANCE WITH THE APPLICABLE REQUIREMENTS OF NFPA 70, NATIONAL ELECTRIC CODE, AND NATIONAL FIRE ALARM AND SIGNALING CODE
3. FIRE ALARM SYSTEMS SHALL BE INSTALLED, TESTED, AND MAINTAINED IN ACCORDANCE WITH THE APPLICABLE REQUIREMENTS OF NFPA 70, NATIONAL ELECTRICAL CODE, AND NFPA 72, NATIONAL FIRE ALARM AND SIGNALING CODE
4. MANUAL FIRE ALARM BOXES SHALL BE USED ONLY FOR FIRE-PROTECTIVE SIGNALING PURPOSES AND SHALL BE ACCESSIBLE, UNOBSTRUCTED, AND VISIBLE
5. MANUAL FIRE ALARM BOX SHALL BE LOCATED WITHIN 60 IN OF EXIT DOORWAYS
6. MANUAL FIRE ALARM BOXES SHALL BE MOUNTED ON BOTH SIDES OF GROUPED OPENINGS OVER 40 FT IN WIDTH, AND WITHIN 60 IN OF EACH SIDE OF THE OPENING
7. MANUAL FIRE ALARM BOXES SHALL BE LOCATED SO THAT NO HORIZONTAL DISTANCE ON THAT FLOOR EXCEEDING 200 FT SHALL NEED TO BE TRAVERSED TO REACH A MANUAL FIRE ALARM BOX
8. FOR FIRE ALARM SYSTEMS USING AUTOMATIC FIRE DETECTION OR WATER FLOW DETECTION DEVICES TO INITIATE THE FIRE ALARM SYSTEM, NOT LESS THAN ONE MANUAL FIRE ALARM BOX SHALL BE PROVIDED TO INITIATE A FIRE ALARM SIGNAL
9. SHOULD A SPRINKLER SYSTEM BE PROVIDED, AN APPROVED ALARM INITIATION DEVICE THAT OPERATES WHEN THE FLOW OF WATER IS EQUAL TO OR GREATER THAN THAT FROM A SINGLE AUTOMATIC SPRINKLER

SPRINKLER SYSTEM NOTES - NFPA 13R

1. THE PROPOSED BUILDING SHALL BE PROTECTED THROUGHOUT BY AN APPROVED SPRINKLER SYSTEM
2. THE REQUIRED AUTOMATIC SPRINKLER SYSTEM SHALL BE IN ACCORDANCE WITH NFPA 13R
3. THE CONTRACTOR SHALL SUBMIT SHOP DRAWINGS TO THE ENGINEER FOR REVIEW PRIOR TO SUBMITTAL TO THE FIRE MARSHAL FOR REVIEW
4. NO WORK SHALL BE PERFORMED UNTIL THE CONTRACTOR IS NOTIFIED IN WRITING BY THE AHJ THAT THE PROPOSED INSTALLATION IS APPROVED

